



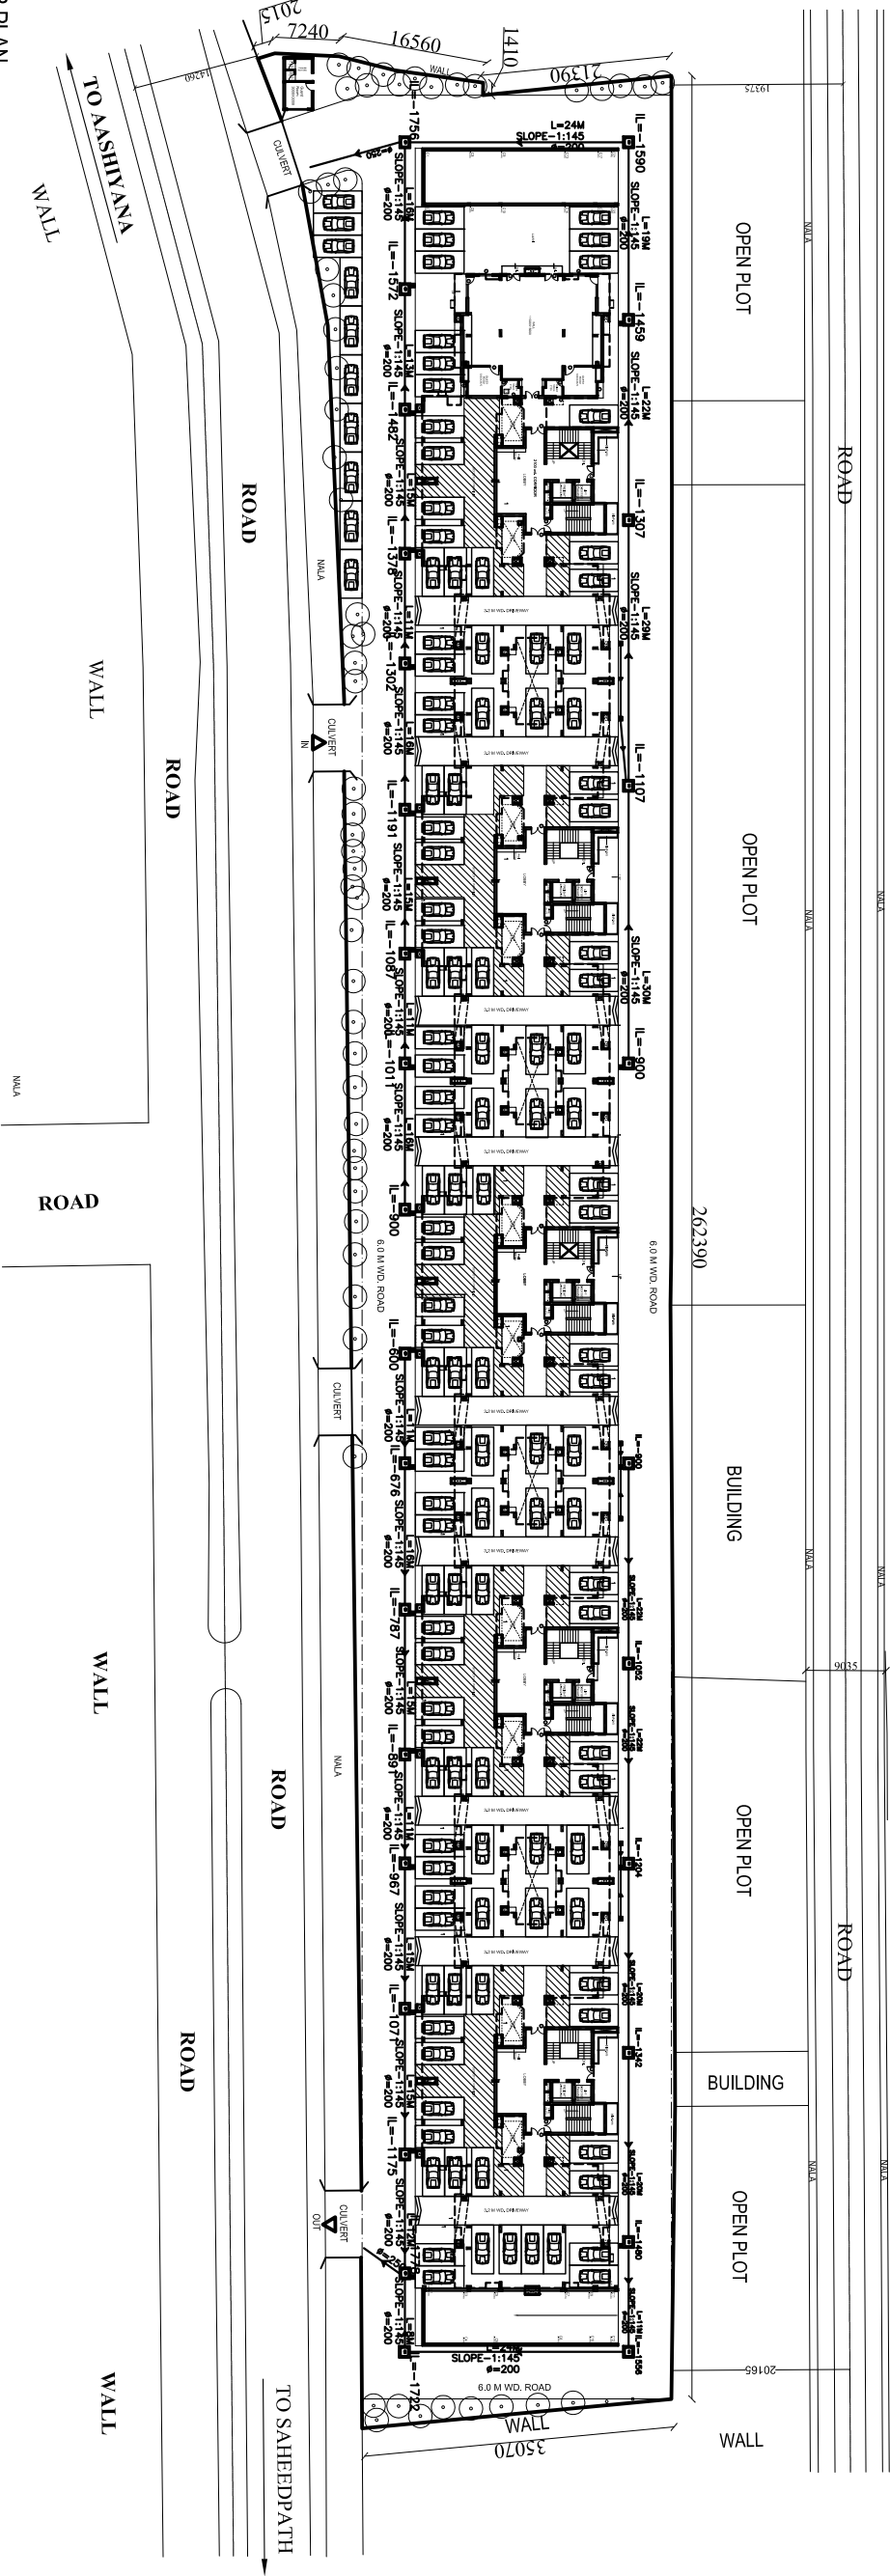

STILT FLOOR PLAN

EXTERNAL SEWER LAYOUT

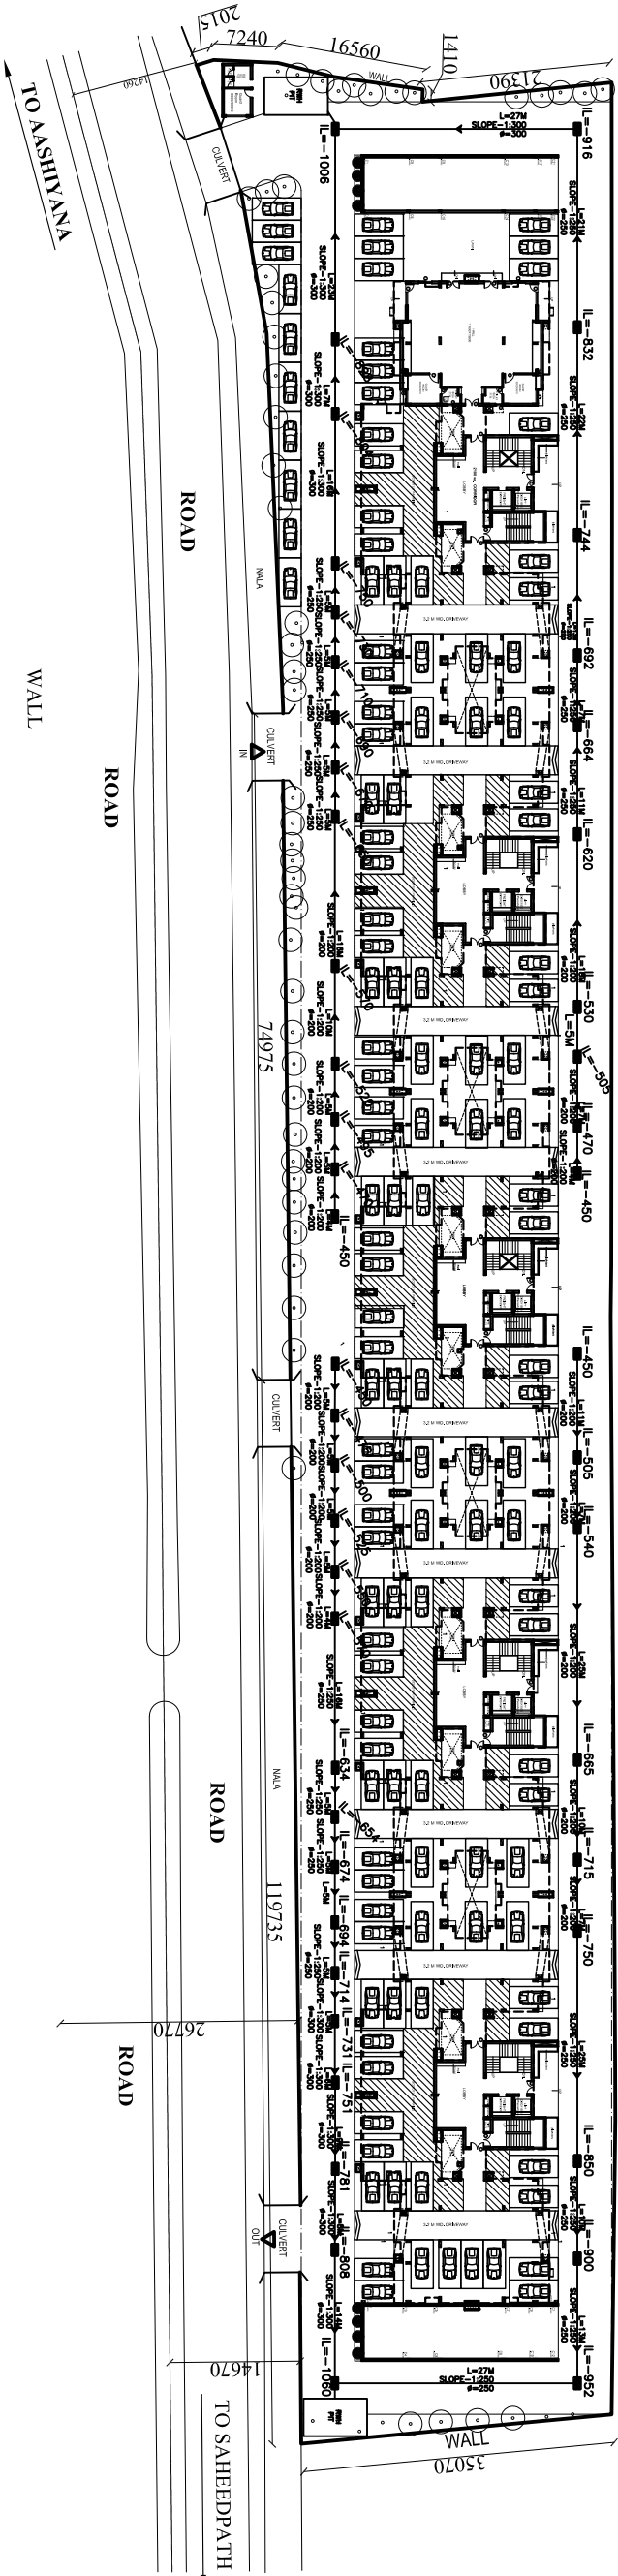

STILT FLOOR PLAN

EXTERNAL CATCH LAYOUT

PROPOSED GROUP HOUSING - ASLESA APARTMENTS
AT PLOT NO. C4, SECTOR -O, MANSAROVAR YOJNA,
KANPUR ROAD ,LDA, LUCKNOW

BUILDING MEP CONSULTANT
TRIVENI CONSULTING ENGINEERS
FLAT NO.-C AVON RESIDENCY
A/18, SECTOR-H ALIGANJ
LUCKNOW
triveniconsultants.iko@gmail.com

ARCHITECT



architects
m u r a l i a g e
architects , interior decorators & muralists
A-3/269 , vibhav khand , gomti nagar , lucknow
phone no.. : 2980139, 2320715

Sheet No
5
Ref No - L-81 AF-979(3)
Date - SEP-16

SERVICES DRAWING
EXTERNAL SEWER & CATCH
LAYOUT
SCALE - 1:400