


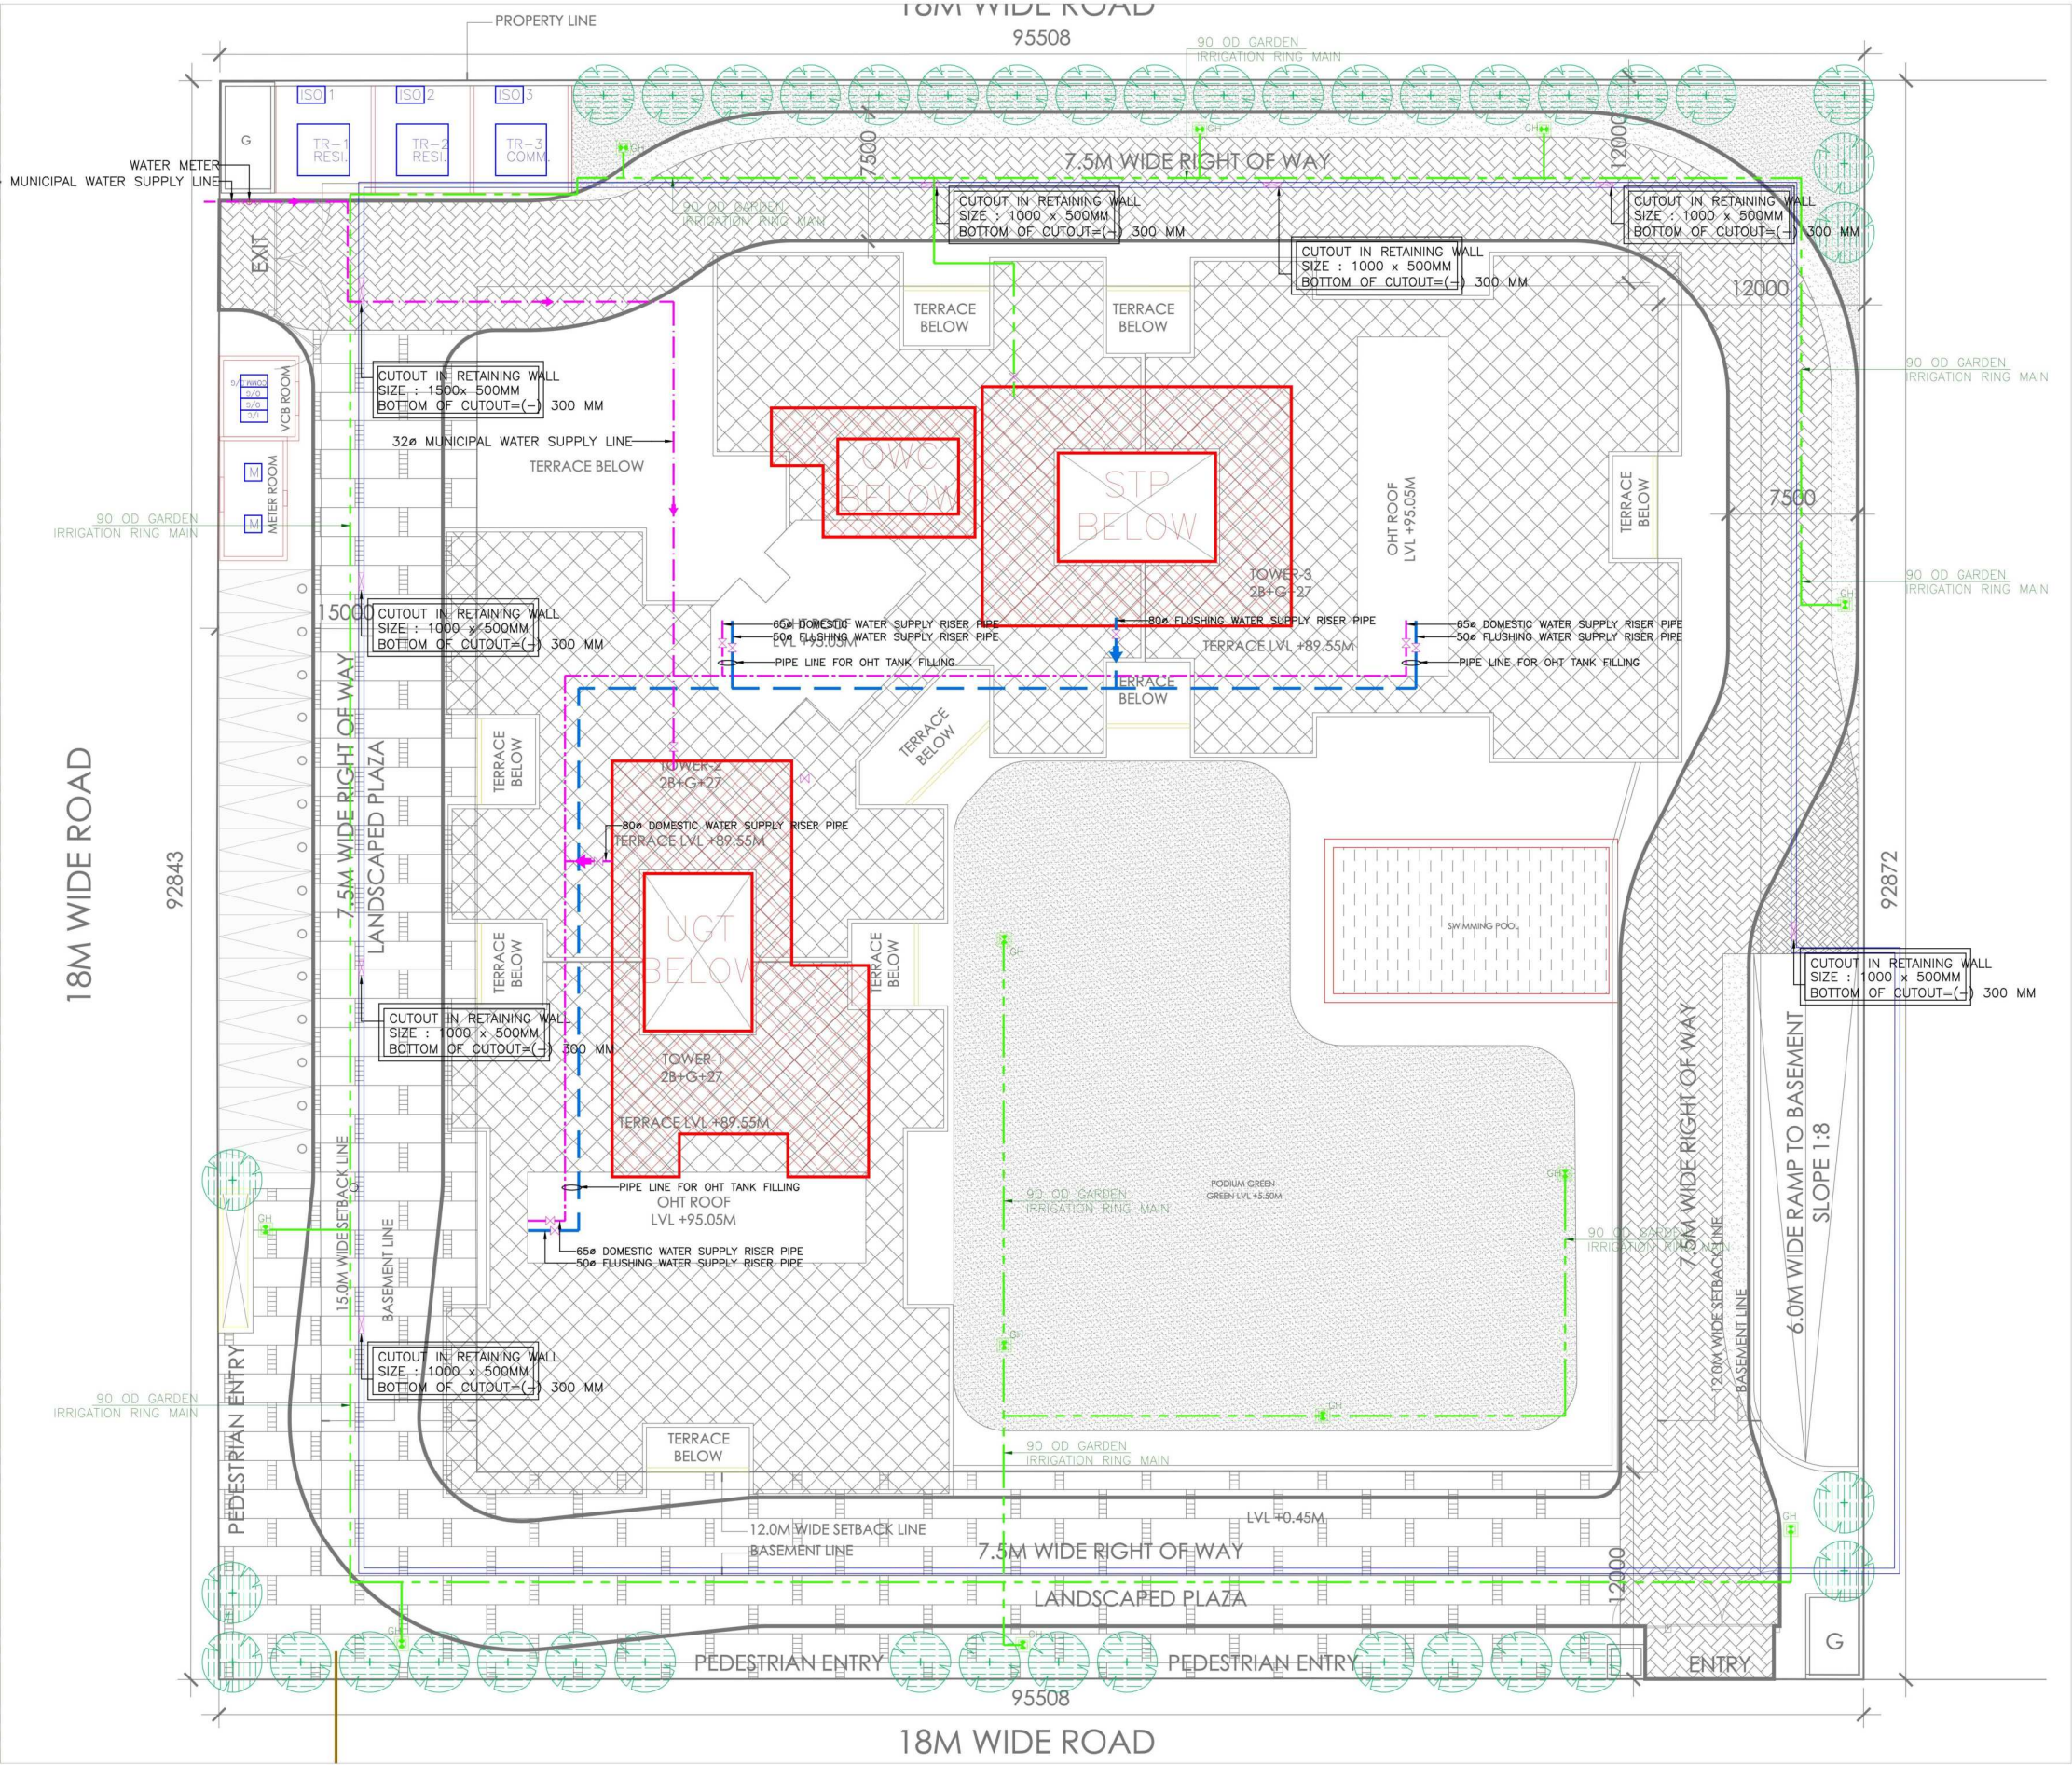

PLUMBING SERVICES LEGEND :	
	SEWER MANHOLE WITH 600ø FRP MANHOLE COVER
	STORM WATER MANHOLE WITH 600ø FRP MANHOLE COVER
	CATCH BASIN (450 x 450) MM WITH 450 x 450 MM FRP M
	CATCH BASIN (600 x 600) MM WITH 600 x 600 MM FRP M
	EXTERNAL SEWER LINE (DIA AS/DESIGN CHART)
	INTERNAL STORM WATER BRANCH LINE, SLOPE=1:190
	110 OD PLANTER DRAIN PIPE AS PER LANDSCAPE, SLOPE=
	STORM WATER LINE (DIA AS/DESIGN CHART)
	DOMESTIC WATER SUPPLY LINE (DIA AS/LAYOUT PLAN)
	FLUSHING WATER SUPPLY LINE (DIA AS/LAYOUT PLAN)
	GARDEN IRRIGATION LINE (DIA AS/LAYOUT PLAN)
	160 OD SUB-SOIL DRAINAGE PIPE
	GARDEN HYDRANT WITH 300 x 300 MM CHAMBER
	R.P. RECHARGE PIT, MANHOLE COVER
	D.C. DESILTING CHAMBER DIA FRP MANHOLE COVER
	EXTERNAL FIRE HYDRANT LINE
	EXTERNAL FIRE HYDRANT

SHEET NO.-1

DRAWING TITLE:-


SITE PLAN
WATER SUPPLY-LAYOUT



SING. OF OWNER :-

Black Opal Ventures LLP
Authorised Signatory

SING. OF LTP :-

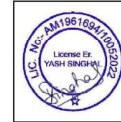

CONSULTING LTP :-

YASH ASSOCIATES
PROJECTS:- ARCHITECTURE, INTERIOR DESIGN
CONSTRUCTION, VALUATION
STUDIO 1 : SHOP 437, FOURTH FLOOR, ADITYA HIGH
STREET COMPLEX, LAL KUAN, GHAZIABAD-201009
STUDIO 2:-B NO. 56, MANSAROVER COLONY
BULANDSHAHR-203001
E-Mail:- er.yashassociates@gmail.com
Mob.- +91-9058882476