


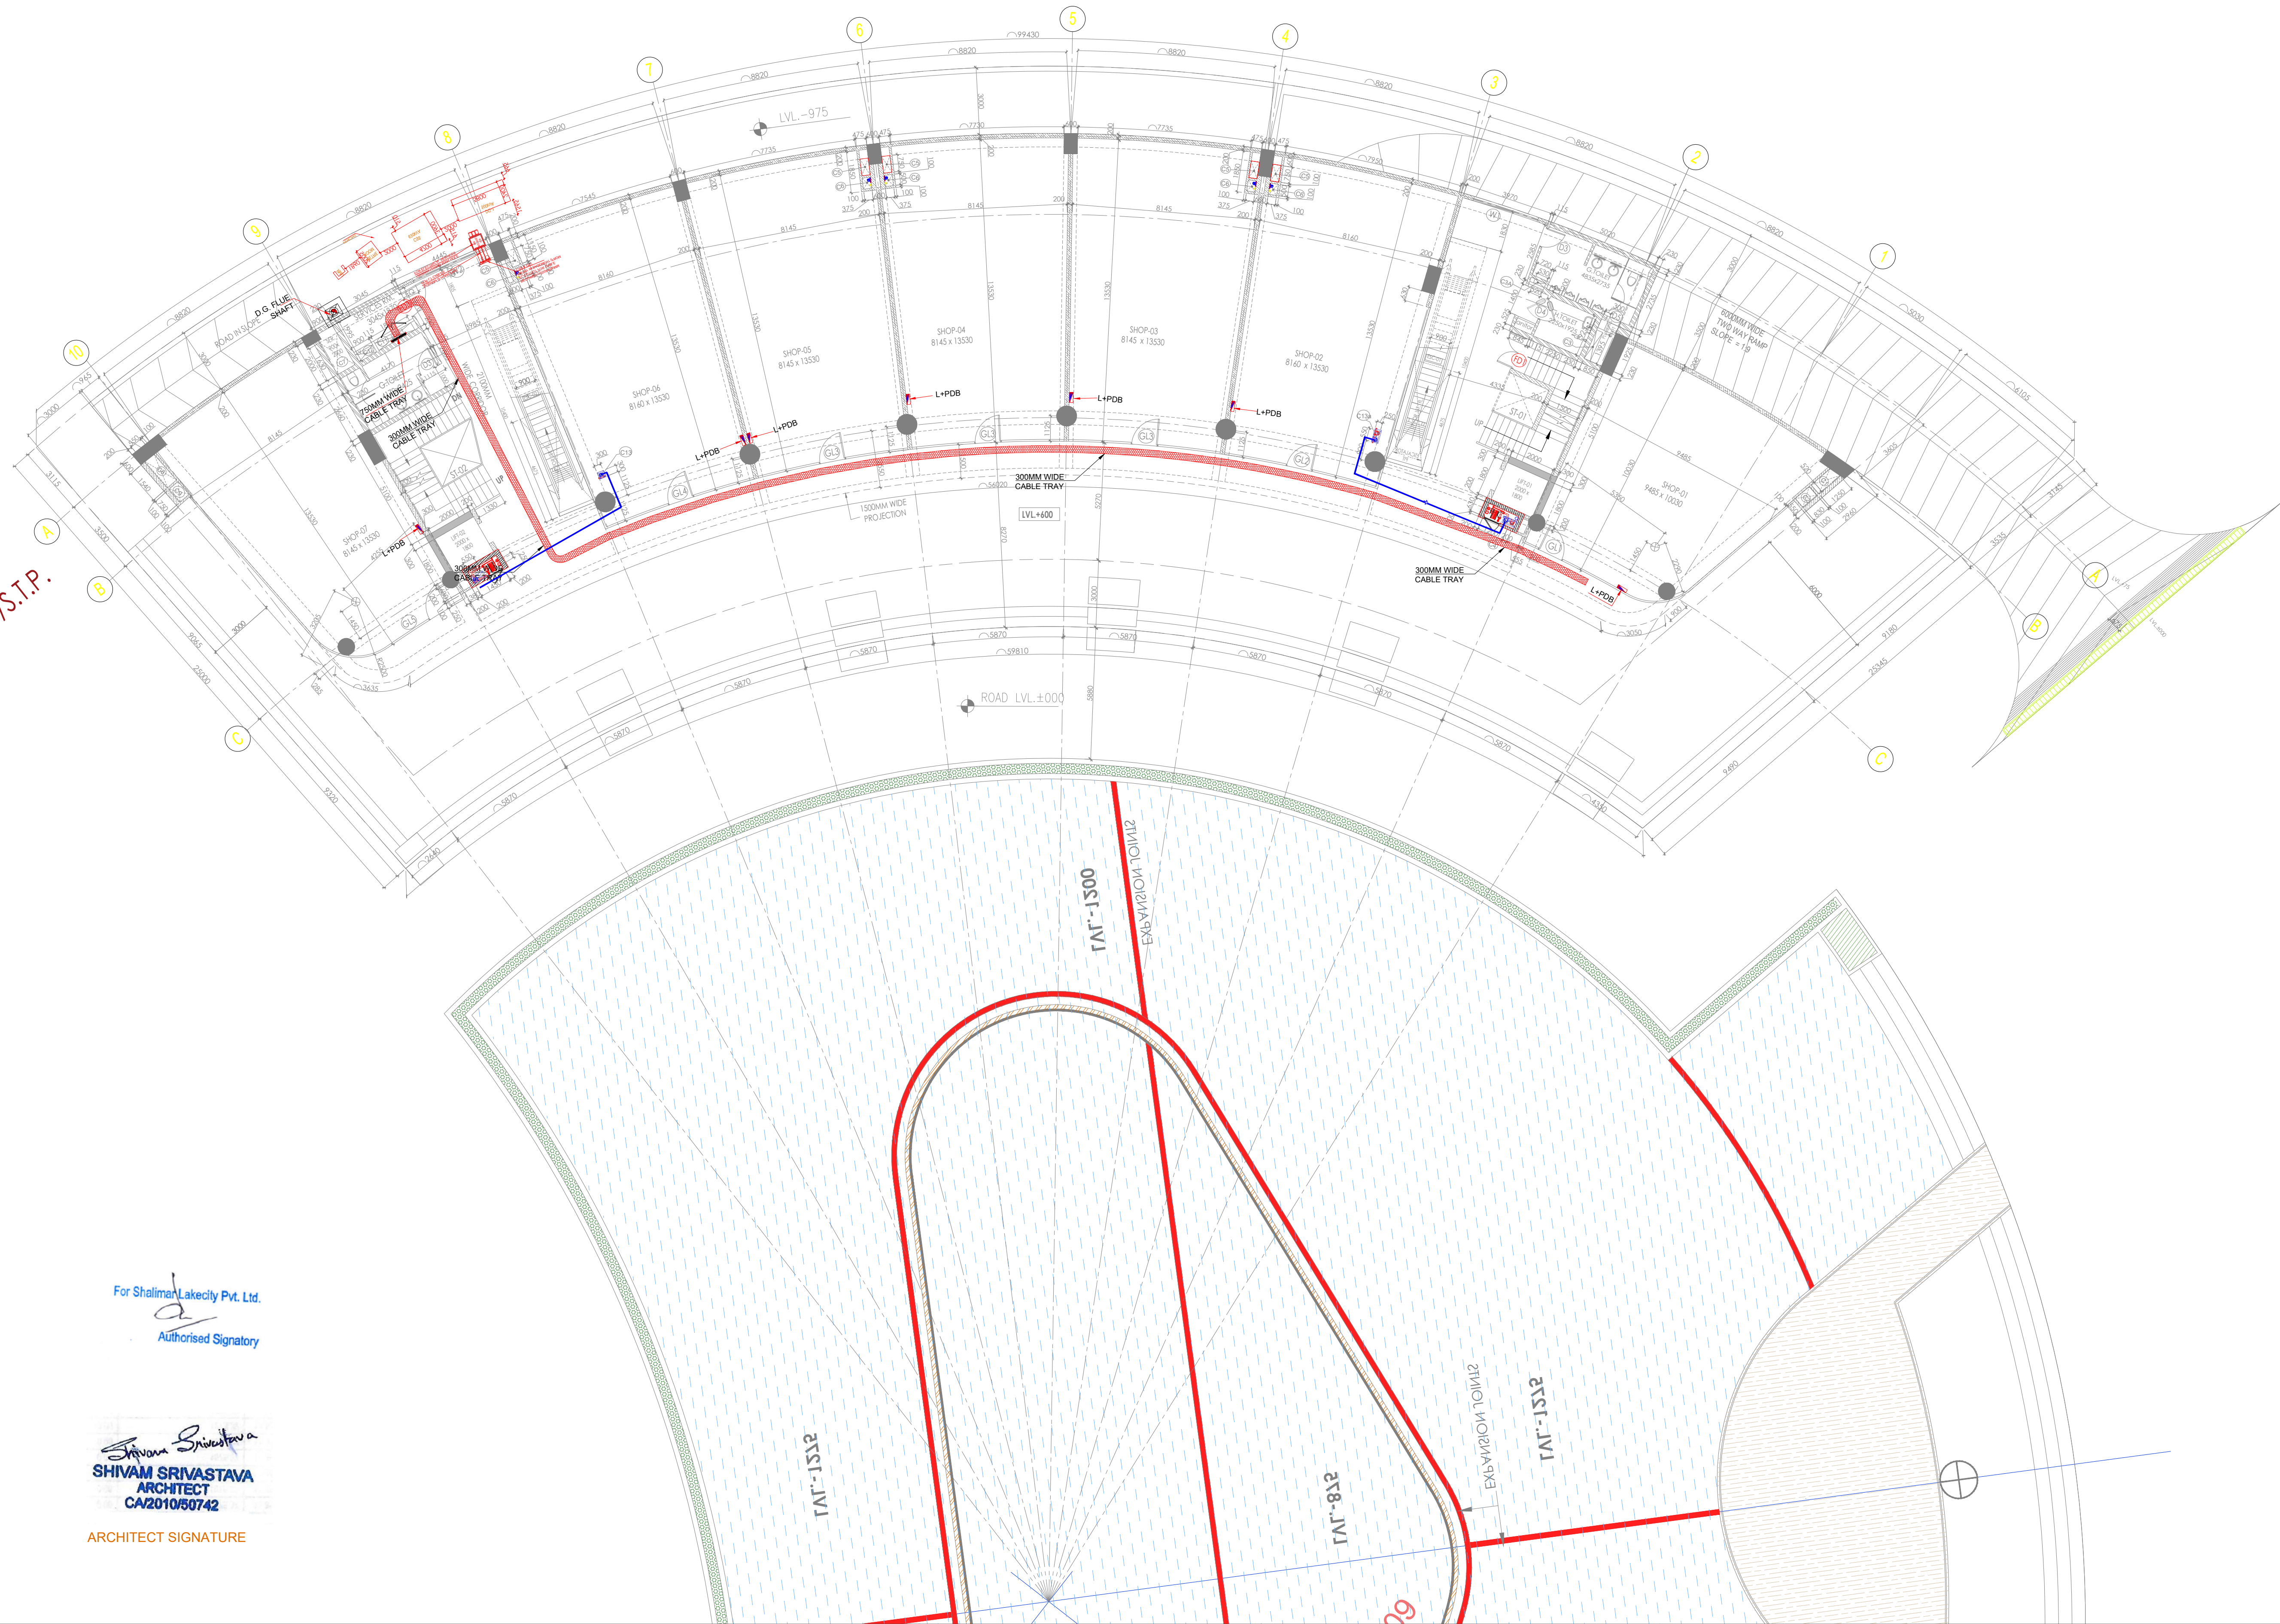

ELECTRICAL LEGEND:-

	CABLE TRAY
	DISTRIBUTION BOARD

COMMERCIAL-02 BUILDING
PLAN FOR M/S A.N.S DEVELOPER
(P). LTD.THROUGH ITS AUTHORIZED
SIGNATORY SHEO JANAM
CHOUDARI AT A.N.S INTEGRATED
TOWNSHIP, SHALIMAR ONE
WORLD, AT VILLAGE, BAGHAMAU,
LUCKNOW(KHASRA NUMBER PART
OF 360,361,362)
PROJECT NAME THE WALK-01

NOTES:-
1. ALL DIMENSIONS ARE IN MM.
2. DO NOT SCALE ANY DIMENSIONS.
3. THIS DRAWING SHALL BE READ IN
CONJUNCTION WITH RELEVANT
ARCHITECTURAL AND STRUCTURAL DRAWINGS.

KEY PLAN

LEGEND

CODE	DESCRIPTION



ATKINS

42mm ARCHITECTURE
D-102 Dr. Ambedkar Colony, Andheria Moch,
New Delhi

PDA Consultants
MEP & Green Building Consultants
REGD OFFICE
PLOT NO-100, SECOND FLOOR,
PATNAGANJ INDUSTRIAL AREA,
GULSHAN-110002, INDIA
TEL:- +91-11-4240830/4240832
E-MAIL:- info@pdaconsultants.in

STRUCTURAL

LANDSCAPE

PROJECT BAGHAMAU INTEGRATED TOWNSHIP
DEVELOPMENT, LUCKNOW
INDIA

ARCHITECT **SAA**
SIKKA ASSOCIATES ARCHITECTS
A-151, 4TH FLOOR, BAGHAMAU ENCLAVE, NEW DELHI, INDIA, 110029
T:- +91-11-42408302 / +91-11-26014811 E:- sikkaarchitects@gmail.com / info@sikkaarchitects.com

SEAL	ISSUED FOR
	INFORMATION & REVIEW
	TENDER
	SUBMISSION
	✓ GFC
	AS BUILT

REVISIONS	DESCRIPTION
#	DATE

SCALE - 1:100 (A1)	
DATE - 14.02.2023	
DRAWN BY - S.K	
CHECKED BY - H.A	

DRAWING COMMERCIAL-2 LAKESIDE GROUND FLOOR ELECTRICAL PLAN	
DWG NO. PDA-178/COMM-2/EL-02	

/S.T.P.

For Shalimar Lakeside Pvt. Ltd.

Authorised Signatory

SHIVAM SRIVASTAVA
ARCHITECT
CA2010/50742

ARCHITECT SIGNATURE