


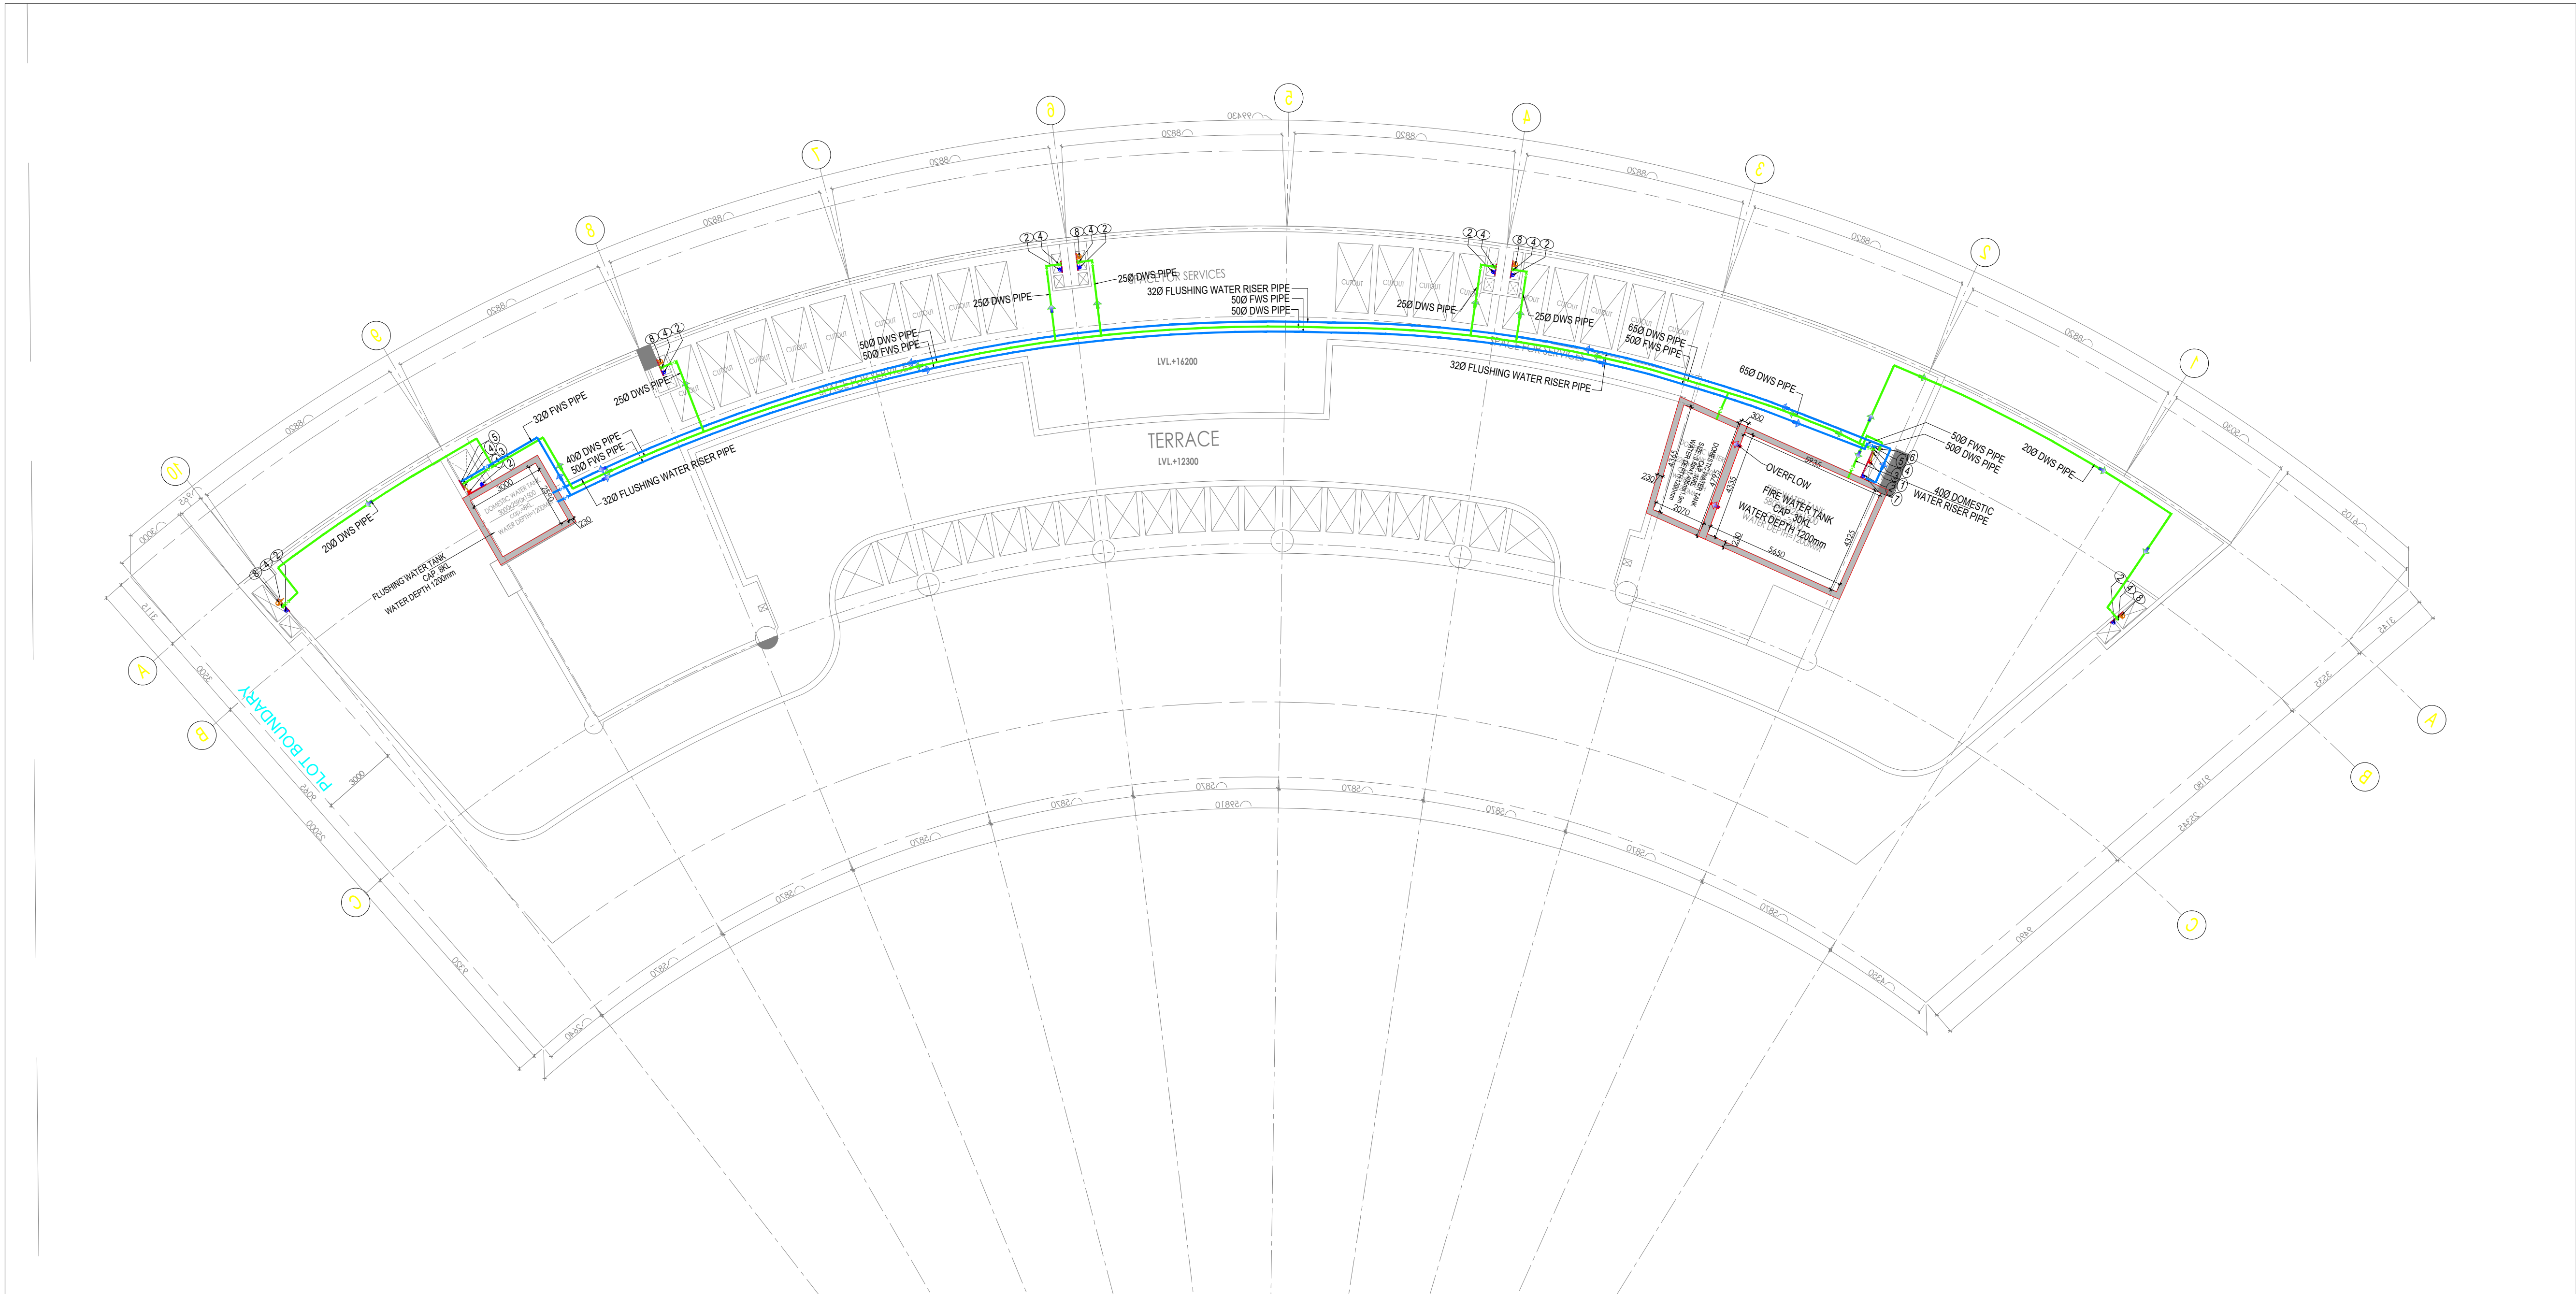

For Shalimar Lakecity Pvt. Ltd.
Authorised Signatory

Shivam Srivastava
SHIVAM SRIVASTAVA
ARCHITECT
CA/2010/50742

ARCHITECT SIGNATURE

LEGEND FOR PLUMBING		
1.		1000 SOIL PIPE
2.		1000 WASTE PIPE
3.		750 ANTISPONAGE PIPE
4.		DOMESTIC WATER SUPPLY PIPE
5.		FLUSHING WATER SUPPLY PIPE
6.		DOMESTIC WATER SUPPLY RISER PIPE
7.		FLUSHING WATER SUPPLY RISER PIPE
8.		1500 RAIN WATER PIPE
		VALVE
		FIRE HOSE CABINET

COMMERCIAL-02 BUILDING
PLAN FOR M/S A.N.S DEVELOPER
(P). LTD.THROUGH ITS AUTHORIZED
SIGNATORY SHEO JANAM
CHOUDARI AT A.N.S INTEGRATED
TOWNSHIP, SHALIMAR ONE
WORLD, AT VILLAGE, BAGHAMAU,
LUCKNOW(KHASRA NUMBER PART
OF 360,361,362)
PROJECT NAME THE WALK-01

NOTES:-
1. ALL DIMENSIONS ARE IN MM.
2. DO NOT SCALE ANY DIMENSIONS.
3. THIS DRAWING SHALL BE READ IN
CONJUNCTION WITH RELEVANT
ARCHITECTURAL AND STRUCTURAL DRAWINGS.

KEY PLAN

LEGEND	CODE	DESCRIPTION

OWNER
SAS GROUP
SAS Hotels & Properties (P) Ltd.
Shalimar Square,
B N Road, Lalbagh, Lucknow

ARCHITECT
ATKINS
42mm ARCHITECTURE
D 102 Dr. Ambedkar Colony, Ancharia Modh,
New Delhi

MEP CONSULTANT
PDA Consultants
MEP & Green Building Consultants
REGD OFFICE:
PLOT NO-108, SECOND FLOOR,
PATARGANJ INDUSTRIAL AREA,
DELHI-110002, INDIA
TEL: +91-11-4308001/142408002
E-MAIL: info@pdaconsultants.in

STRUCTURAL
NNC DESIGN INTERNATIONAL
CONSULTING STRUCTURAL ENGINEERS
P-101, 1ST FLOOR, 1ST STAGE, INDUSTRIAL AREA,
DELHI-110002, INDIA
TEL: +91-11-4308001/142408002
E-MAIL: info@nncdesign.com

LANDSCAPE
NNC DESIGN INTERNATIONAL
CONSULTING LANDSCAPE ARCHITECTS
P-101, 1ST FLOOR, 1ST STAGE, INDUSTRIAL AREA,
DELHI-110002, INDIA
TEL: +91-11-4308001/142408002
E-MAIL: info@nncdesign.com

PROJECT
BAGHAMAU INTEGRATED TOWNSHIP
DEVELOPMENT, LUCKNOW
INDIA


ARCHITECT
SIKKA ASSOCIATES ARCHITECTS
P-101, 1ST FLOOR, 1ST STAGE, INDUSTRIAL AREA,
DELHI-110002, INDIA
TEL: +91-11-4308001/142408002
E-MAIL: info@sikkaassociates.com

SEAL
INFORMATION & REVIEW
TENDER
SUBMISSION
BID
AS BUILT

REVISIONS	#	DATE	DESCRIPTION

SCALE - 1:100 (A1)
DATE - 02.04.2025
DRAWN BY - M.A
CHECKED BY - P.J

DRAWING
WATER SUPPLY LAYOUT
COMMERCIAL-3 LAKESIDE
UPPER TERRACE PLAN
DWG NO. PDA-178/COMM-2/FF/PL/WS-06

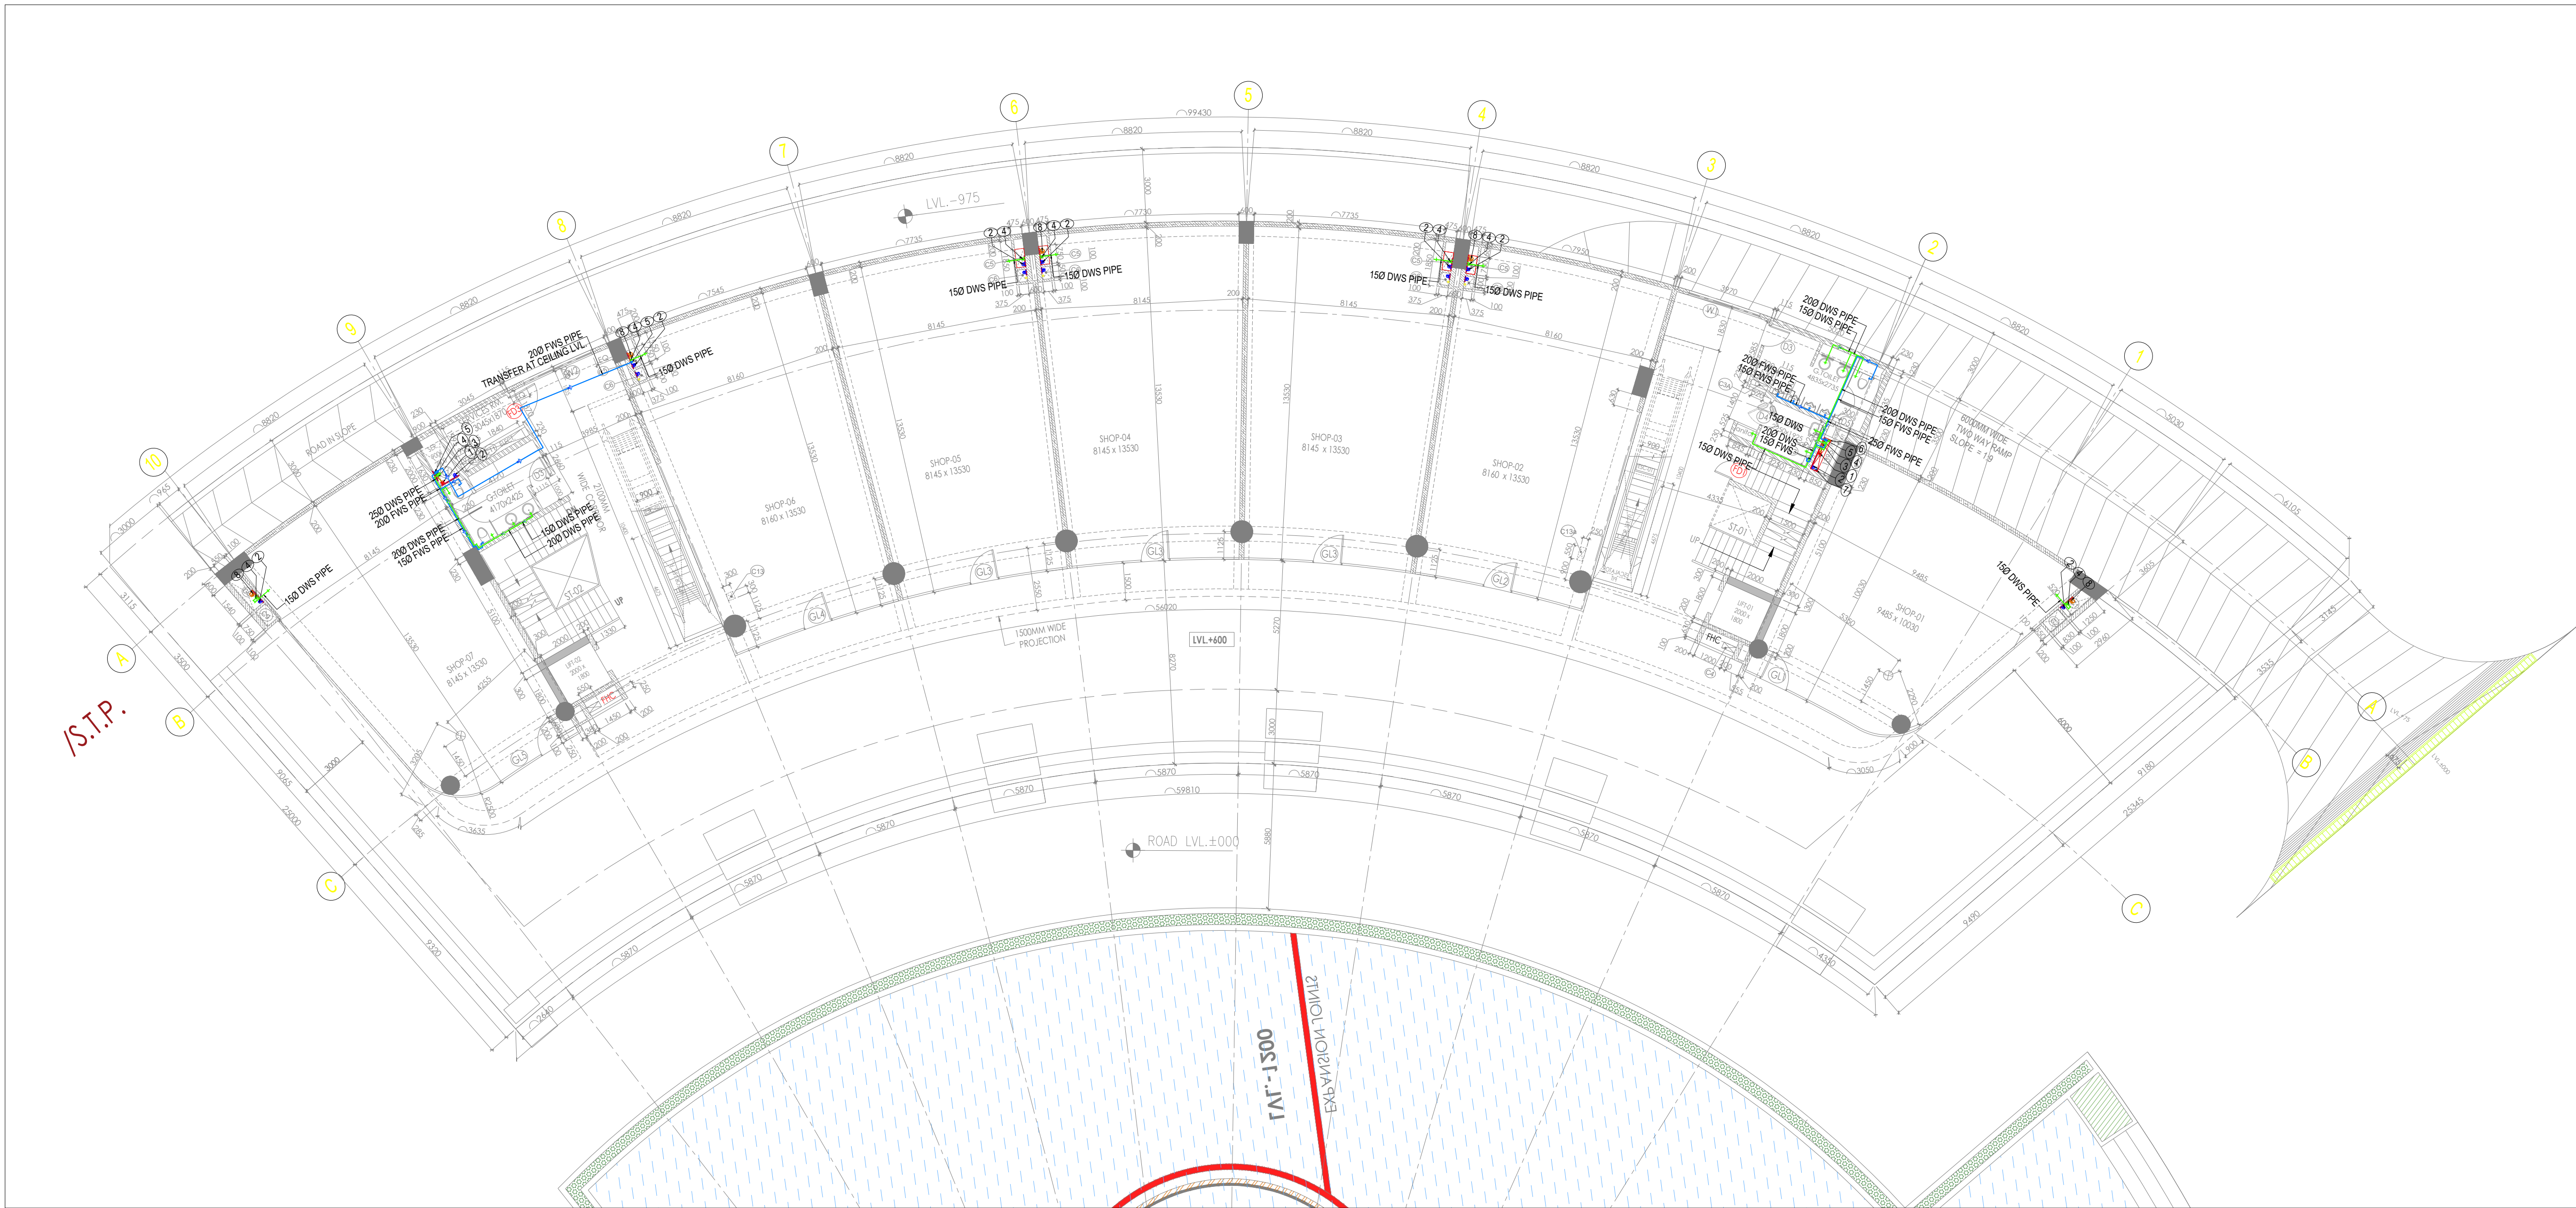

COMMERCIAL-02 BUILDING
PLAN FOR M/S A.N.S DEVELOPER
(P). LTD.THROUGH ITS AUTHORIZED
SIGNATORY SHEO JANAM
CHOUDARI AT A.N.S INTEGRATED
TOWNSHIP, SHALIMAR ONE
WORLD, AT VILLAGE, BAGHAMAU,
LUCKNOW(KHASRA NUMBER PART
OF 360,361,362)
PROJECT NAME THE WALK-01

NOTES:-
1. ALL DIMENSIONS ARE IN MM.
2. DO NOT SCALE ANY DIMENSIONS.
3. THIS DRAWING SHALL BE READ IN
CONJUNCTION WITH RELEVANT
ARCHITECTURAL AND STRUCTURAL DRAWINGS.

KEY PLAN

LEGEND
CODE
DESCRIPTION

OWNER



SAS GROUP
SAS Homes & Properties (P) Ltd.
Shalimar Square,
B N Road, Lucknow

ARCHITECT



ATKINS
42mm ARCHITECTURE
D 102 Dr. Ambedkar Colony, Andheria Modh,
New Delhi

MEP CONSULTANT



PDA Consultants
MEP & Green Building Consultants
REGD OFFICE
PLOT NO-190 SECOND FLOOR
PATIPARTANA INDUSTRIAL AREA
DELHI-110092, INDIA
TEL:-91-11-4248050/4248052
E-MAIL:- delhi@pdaconsultants.in

STRUCTURAL



NMC DESIGN INTERNATIONAL
CONSULTING STRUCTURAL ENGINEERS
100, WARDHA ROAD, NEW DELHI
DELHI-110002, INDIA
TEL:-91-11-4248050/4248052
E-MAIL:- delhi@nmcdesigninternational.in

ARCHITECT



SIKKA ASSOCIATES ARCHITECTS
A-201, OFFICE AVENUE, SARANSWARI ENCLAVE, NEW DELHI INDIA-110029
T:-91-11-4248050/4248052 E:-delhi@sikkaassociates.com

PROJECT

BAGHAMAU INTEGRATED TOWNSHIP
DEVELOPMENT, LUCKNOW
INDIA

ARCHITECT



SIKKA ASSOCIATES ARCHITECTS
A-201, OFFICE AVENUE, SARANSWARI ENCLAVE, NEW DELHI INDIA-110029
T:-91-11-4248050/4248052 E:-delhi@sikkaassociates.com

SEAL

ISSUED FOR
INFORMATION & REVIEW
TENDER
SUBMISSION
☒ GFC
AS BUILT

REVISIONS	DESCRIPTION
#	DATE

SCALE - 1:100 (A1)

DATE - 02.04.2025

DRAWN BY- M.A

CHECKED BY- P.J

DRAWING

WATER SUPPLY LAYOUT
COMMERCIAL-2 LAKESIDE
GROUND FLOOR PLAN

DWG NO. PDA-178/COMM-2/FF/PL/WS-02

For Shalimar Lakeside Pvt. Ltd.
Authorised Signatory

Shivam Srivastava
SHIVAM SRIVASTAVA
ARCHITECT
CA/2010/50742

ARCHITECT SIGNATURE

LEGEND FOR PLUMBING		
1.		1000 SOIL PIPE
2.		1000 WASTE PIPE
3.		750 ANTISPONAGE PIPE
4.		DOMESTIC WATER SUPPLY PIPE
5.		FLUSHING WATER SUPPLY PIPE
6.		DOMESTIC WATER SUPPLY RISER PIPE
7.		FLUSHING WATER SUPPLY RISER PIPE
8.		1500 RAIN WATER PIPE
		VALVE
		FIRE HOSE CABINET