


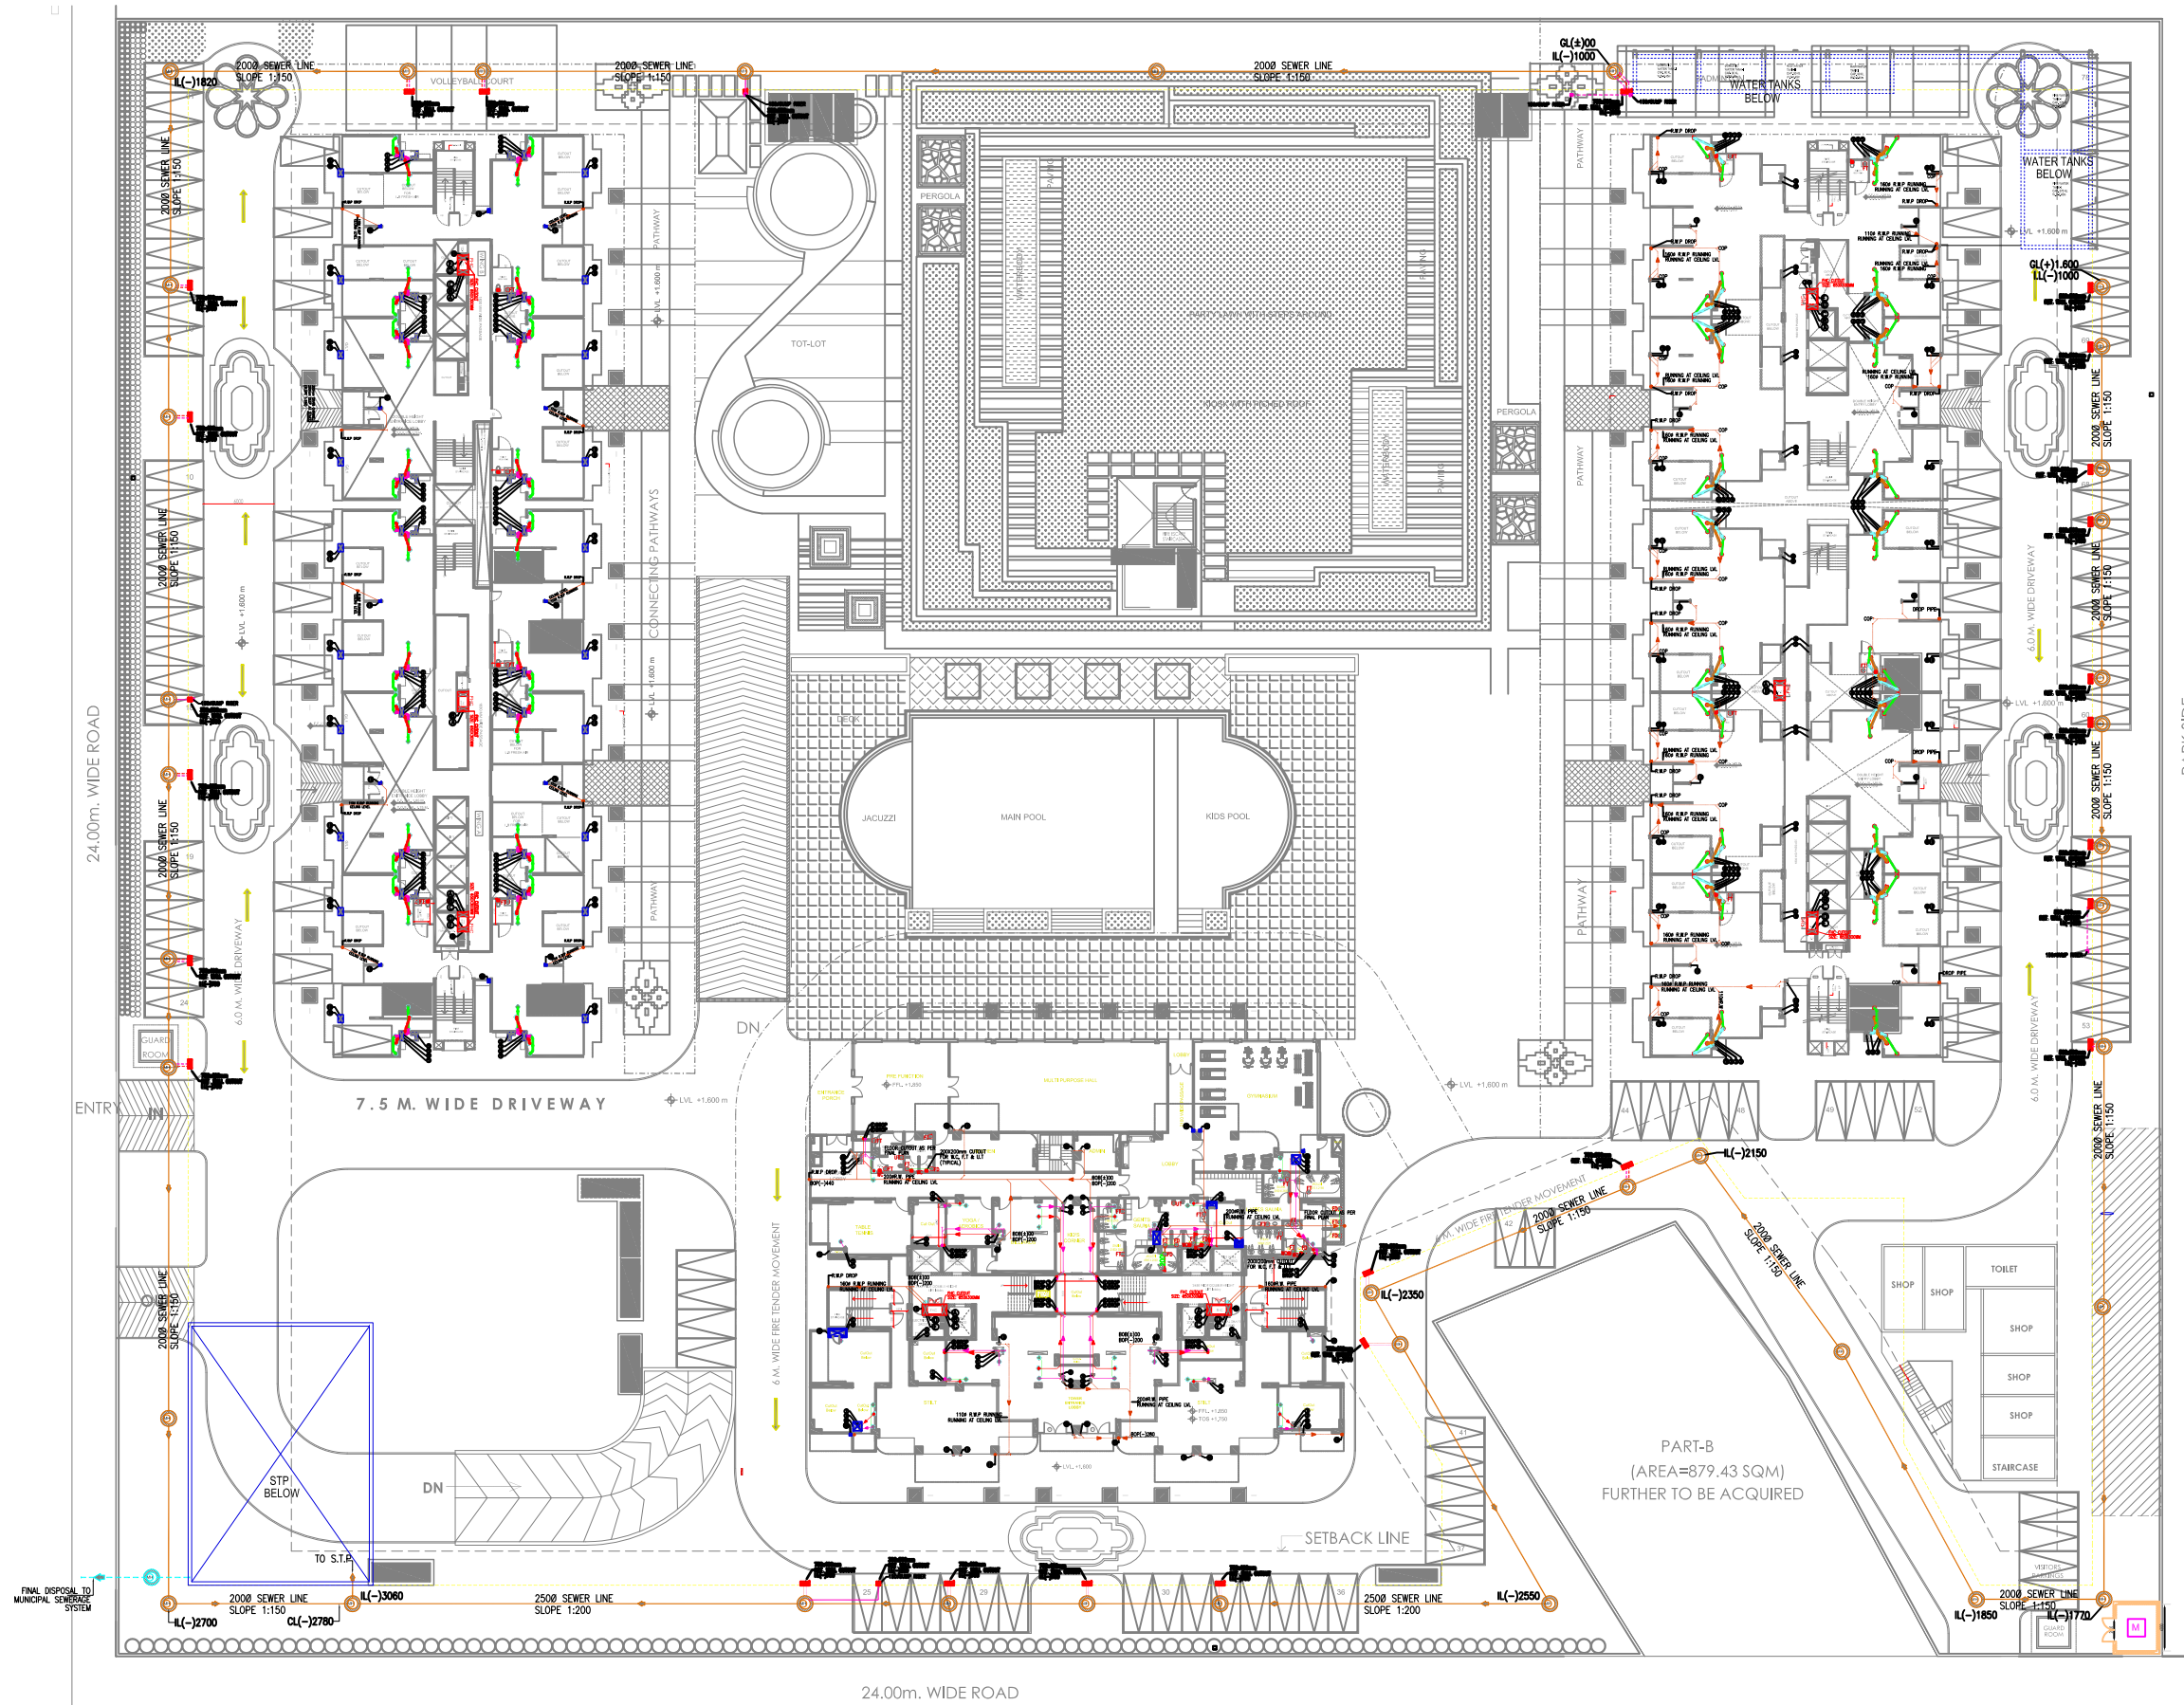

NOTE	
MANHOLE SIZE	MANHOLE DEPTH
900x800mm	750-900mm
1200 MM DIA	900-2300mm
1500 MM DIA	2310-9000mm

LEGEND :-	
SYMBOL	DESCRIPTION
	SEWER LINE
	STORM LINE
	FIRE HYDRANT LINE
	GARDEN HYDRANT LINE
	MUNICIPAL LINE/TUBE WELL LINE
	900#/1200# SEWER MANHOLE
	900#/1200# STORM MANHOLE
	SEWER MANHOLE 900x800mm
	STORM MANHOLE 900x800mm
	CATCH BASIN 500x450mm
	GH GARDEN HYDRANT
	TW TUBE WELL

SUBMISSION DRAWING

PROJECT:

PROPOSED SUBMISSION DRAWINGS
FOR PROPOSED GROUP HOUSING AT
PLOT No:- GH-01/B, SECTOR-10,
GREATER NOIDA WEST (U.P) FOR
M/s HEBE INFRASTRUCTURE PVT. LTD.

DRAWING TITLE :

SEWERAGE LAYOUT
SITE PLAN

OWNER'S SIGN		ARCHITECT'S SIGN	
SCALE 1:350	DEALT BY	DATE - MAY-2016	
DESIGN BY	CHECKED BY	DRG. No.	

SD-06