

NOTE:-
ALL TERRACE & SHAFT WATER SUPPLY PIPE SHALL BE GI.


ALL INTERNAL WATER SUPPLY PIPE SHALL BE CPVC

ALL VERTICAL RAIN WATER PIPE WILL BE

DISCHARGE 150 mm ABOVE FROM GROUND FINISH LVL.

EXTERNAL PIPE DIA & SEWERAGE MANHOLE LEVEL REFER SITE PLAN

PLUMBING LEGENDS:-	MATERIAL
1. 110 OD (SWR) SOIL & VENT PIPE	uPVC (SWR) (TYPE-B)
2. 110 OD (SWR) WASTE & VENT PIPE	uPVC (SWR) (TYPE-B)
3. 75 OD ANTISTYPHONAGE VENT PIPE	(uPVC) (TYPE-A)
4. COLD WATER SUPPLY DN. TAKE PIPE (DOM.) TOP TWO FLOOR	(GI) MEDIUM DUTY
5. COLD WATER SUPPLY DN. TAKE PIPE (DOMESTIC.)	(GI) MEDIUM DUTY
6. DOMESTIC COLD WATER SUPPLY RISER PIPE	(GI) MEDIUM DUTY
7. 75 OD (SWR) RAIN WATER PIPE FOR BALCONY	uPVC (TYPE-A)
8. 75 OD (SWR) WASTE PIPE FOR UTILITY	uPVC (TYPE-B)
9. 110 OD (SWR) RAIN WATER PIPE	uPVC (TYPE-A)
11. 100Ø M.S FIRE PIPE	(M.S)
WATER TYPE 9lit. CO2 FIRE EXTINGUISHER	
4.5 Kg CO2 FIRE EXTINGUISHER	

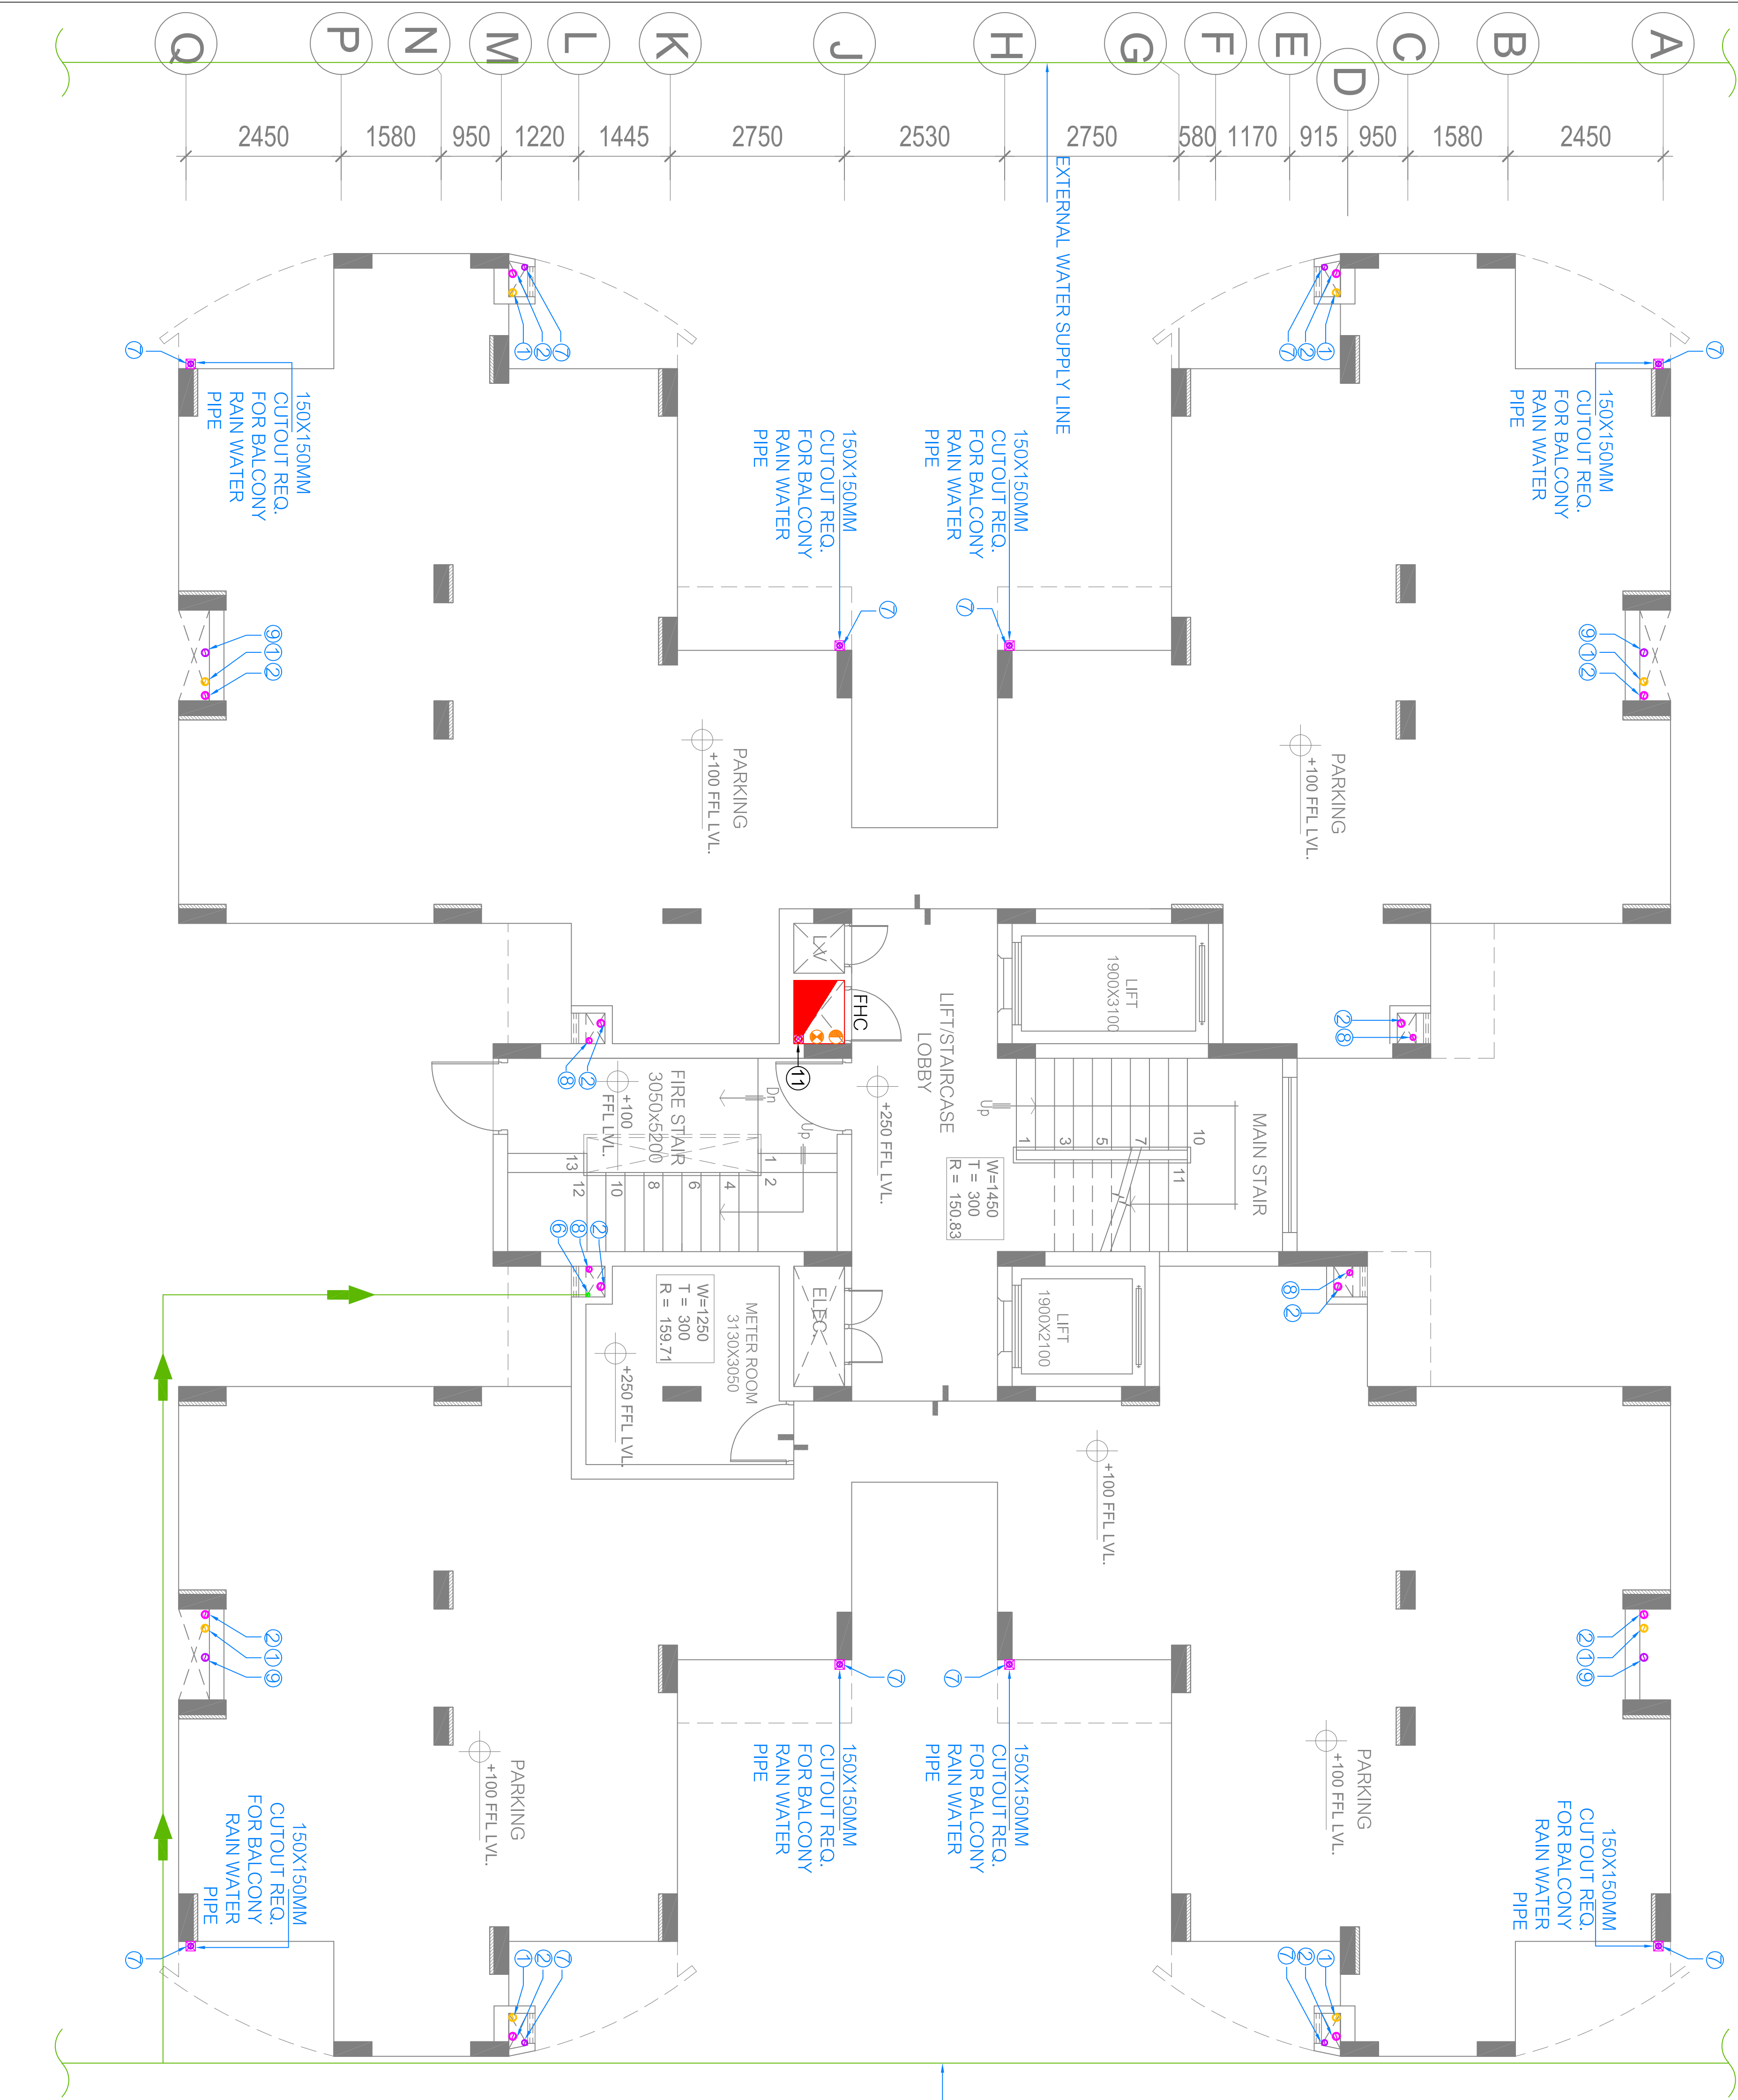

REV. NO.	DATE	DESCRIPTIONS
WORKING DRAWING		
PROJECT		
ANSALS ELEGANCE PROPOSED GROUP HOUSING ON KHASRA NO. 581 594, 597 AND 600 VILLAGE DASNA, GHAZIABAD.		
DRG. TITLE		
PLUMBING LAYOUT WATER SUPPLY PLAN TOWER - C		
DRG. NO. SERV / 1055/GZB-GH-DASNA/C/PL-01		
DEALT BY	DATE	23-01-15
CHECKED BY	SCALE	1:50
MANOJ KUMAR SR. MANAGER PHE SERVICES		ADITTA KUMAR GUPTA SR. G.M (SERVICES)
ANSAL HOUSING & CONSTRUCTION LTD.		
15 - UGF, INDRA PRAKASH, 21, BARAKHANABA ROAD, NEW DELHI - 110 001		

