


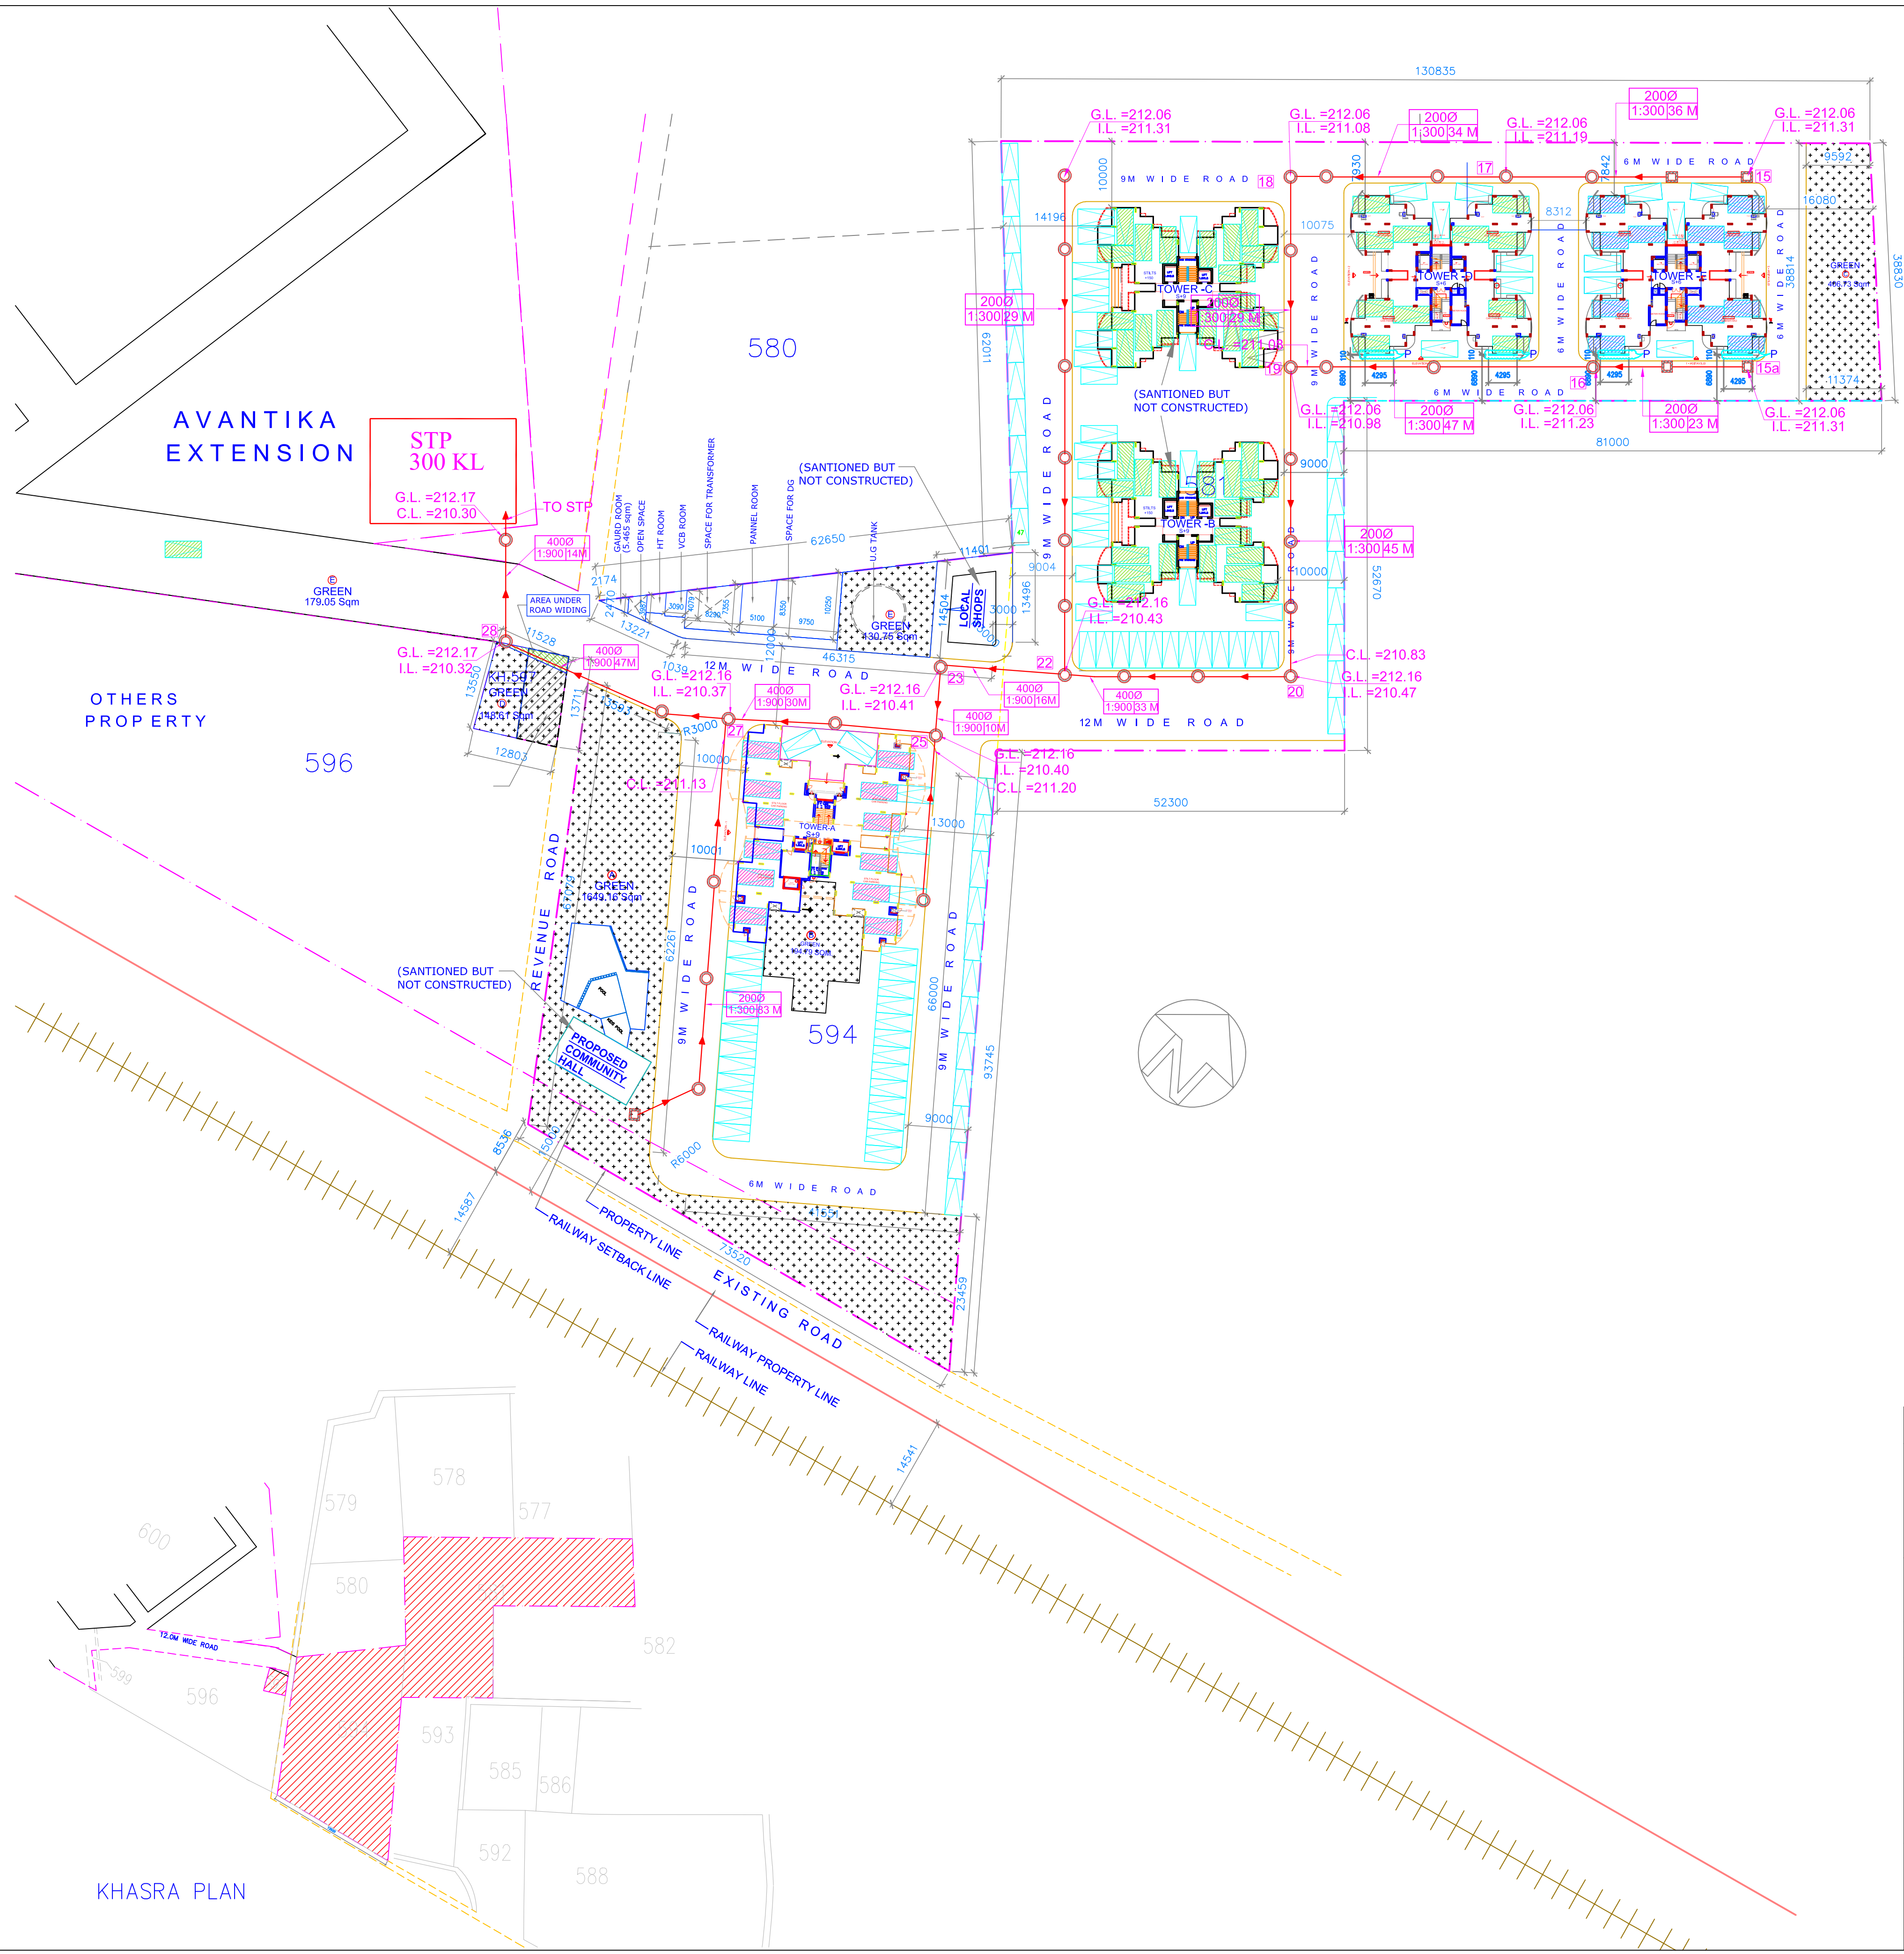

PLUMBING LEGEND

	MAIN SEWER LINE
	CIRCULAR MANHOLE
	REC MANHOLE

PIPE DIA.
SLOPE / LENTGH

PART COMPLETION

PROJECT :-
GROUP HOUSING
ON KHASRA NO. 581 594 AND 597,
VILLAGE DASNA,
GHAZIABAD.

TITLE :-
SEWERAGE LAYOUT PLAN

DEALT S. RAWAT DATE 24-11-2015

CHECKED BY M. KUMAR SCALE 1: 500

DWG NO. SERV/1055/GZB-GH-DASNA/COMP/PL-01

ARCHITECT'S SIGNATURE

OWNER'S SIGNATURE

ANSAL HOUSING &
CONSTRUCTION LTD.

15, UGF, INDRA PRAKASH
21 BARAKHAMBHA ROAD
NEW DELHI - 110 001