

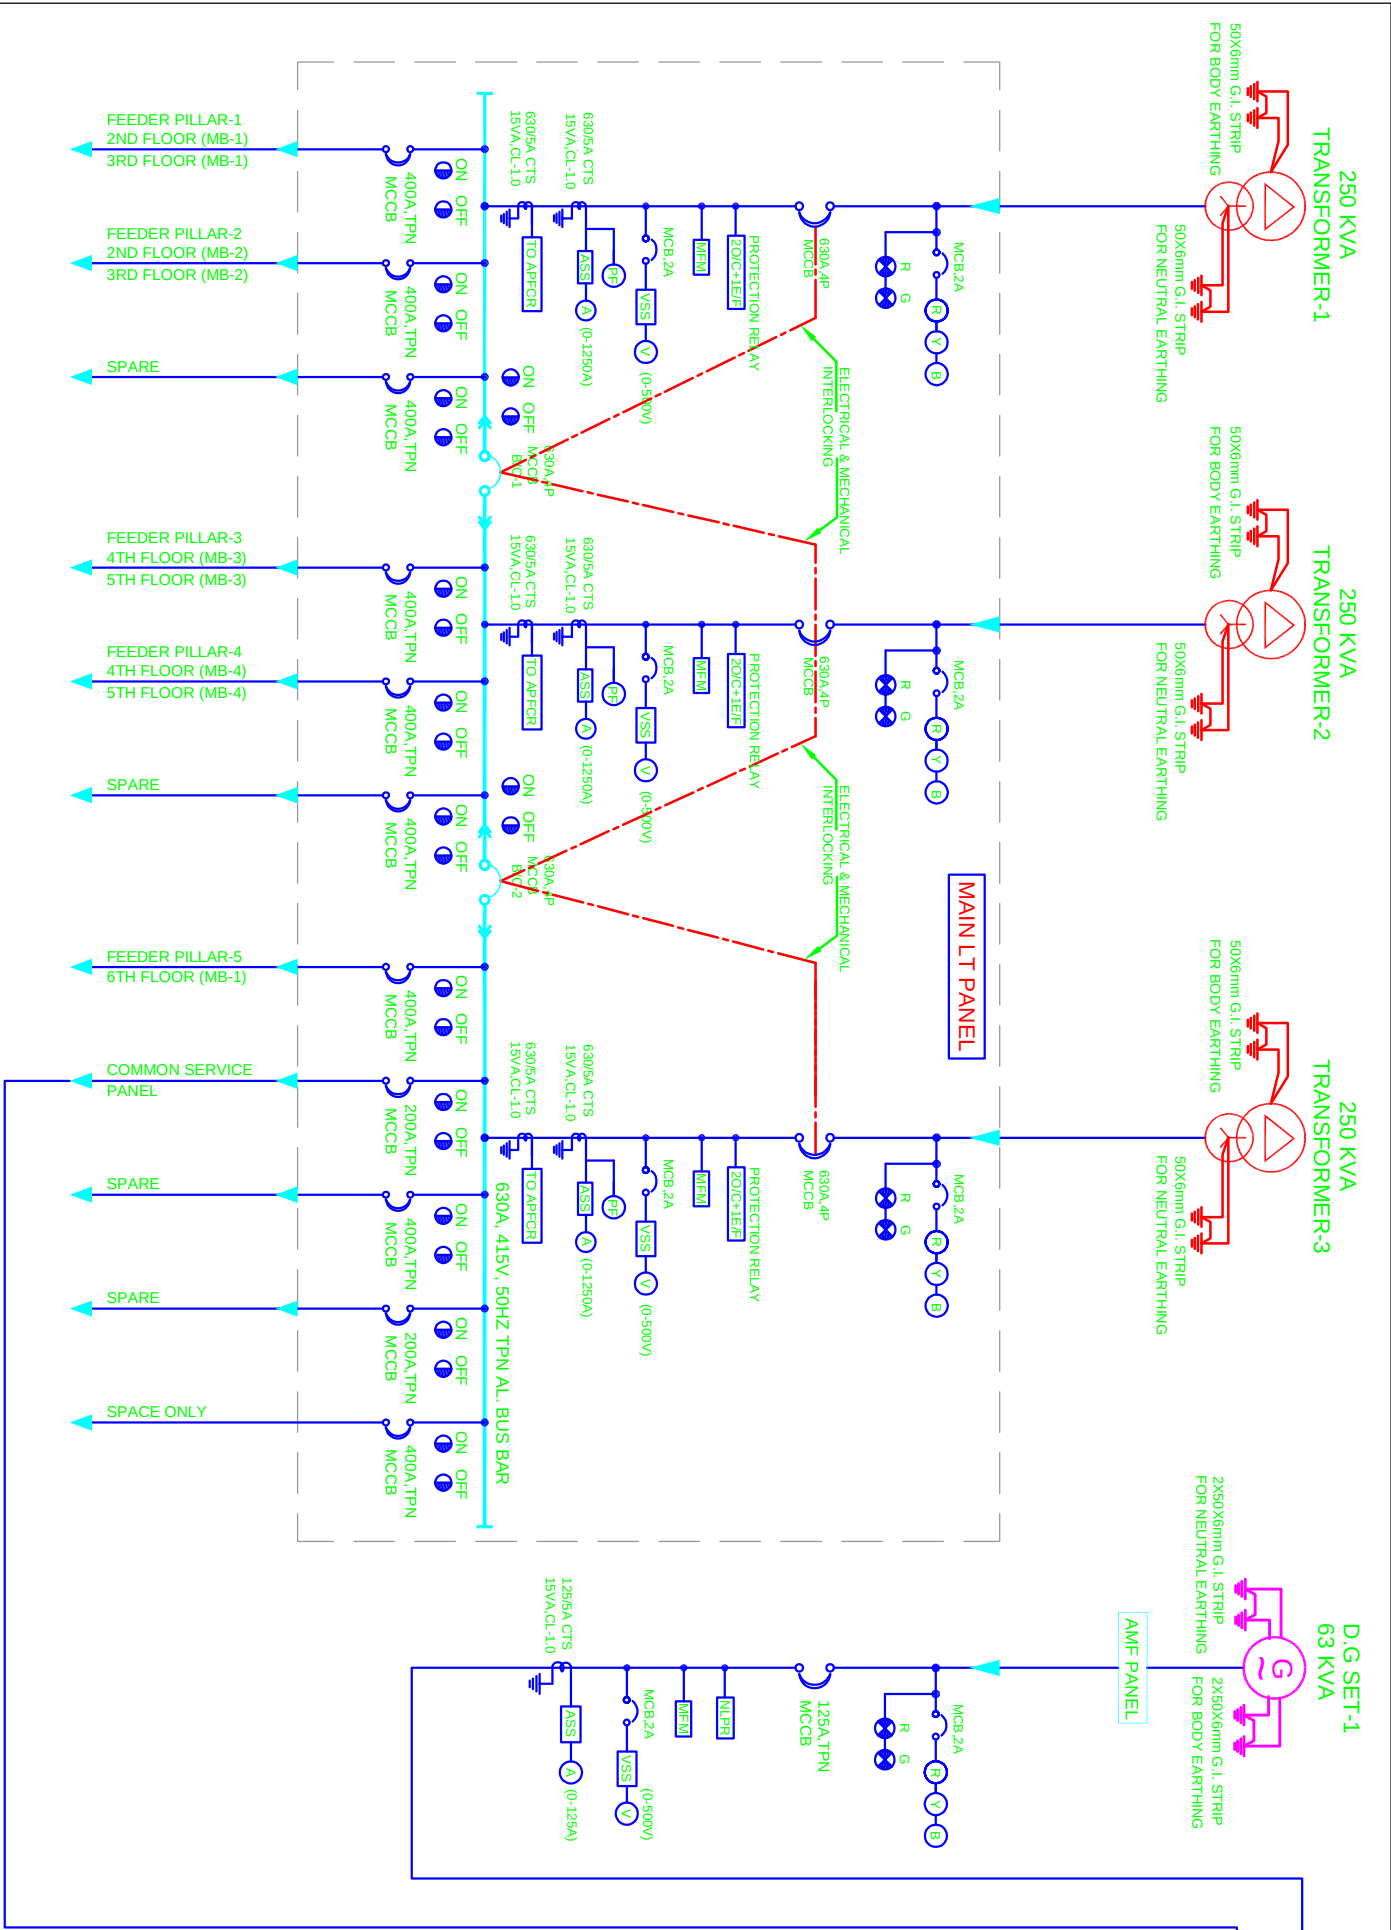


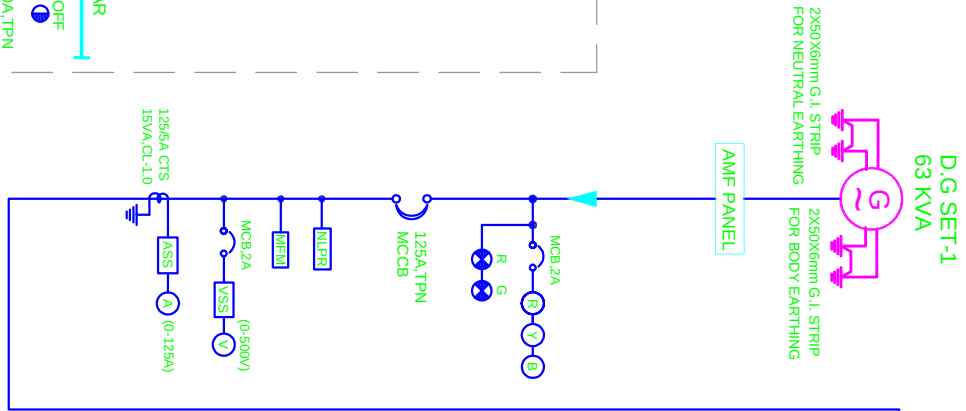

ELECTRICAL LEGENDS :-	
	MINIATURE CIRCUIT BREAKER
	MOULDED CASE CIRCUIT BREAKER
	VOLTMETER
	AMMETER
	ON INDICATOR
	OFF INDICATOR
	PHASE INDICATOR LAMP
	VOLTMETER SELECTOR SWITCH
	AMMETER SELECTOR SWITCH
	AUTOMATIC POWER FACTOR CORRECTION RELAY
	POWER TRANSFORMER
	DIESEL GENERATOR SET
	CURRENT TRANSFORMER
	MULTI FUNCTION METER
	NEUTRAL LOSS PROTECTION RELAY
	O/C, EARTH FAULT PROTECTION RELAY
	E/F, TIME OVER CURRENT PROTECTION RELAY
	EARTHING

PROJECT	
SUMANGALAM CORPORATE SUITES	
RAJNAGAR DIST CENTER, GHAZIABAD (UP)	
TITLE	
SINGLE LINE DIAGRAM	
LT DISTRIBUTION SYSTEM	
(TRANSFORMER, D.G PANEL, MAIN L.T PANEL & METER BOARDS)	
DEALT BY :- P.S. PATWAL	DATE:- 06-07-2018
CHECKED BY :-	SCALE N.T.S
DRG. NO.	
SERV. /1020GZB-RNDC /SLD/EL-01	
ADITYA GUPTA	
SR. G.M. (SERVICES)	
ansal housing & construction L.TD.	
15, UGF INDRAPRAKASH	
21 BARAKHAMBA ROAD	
NEW DELHI - 110 001	

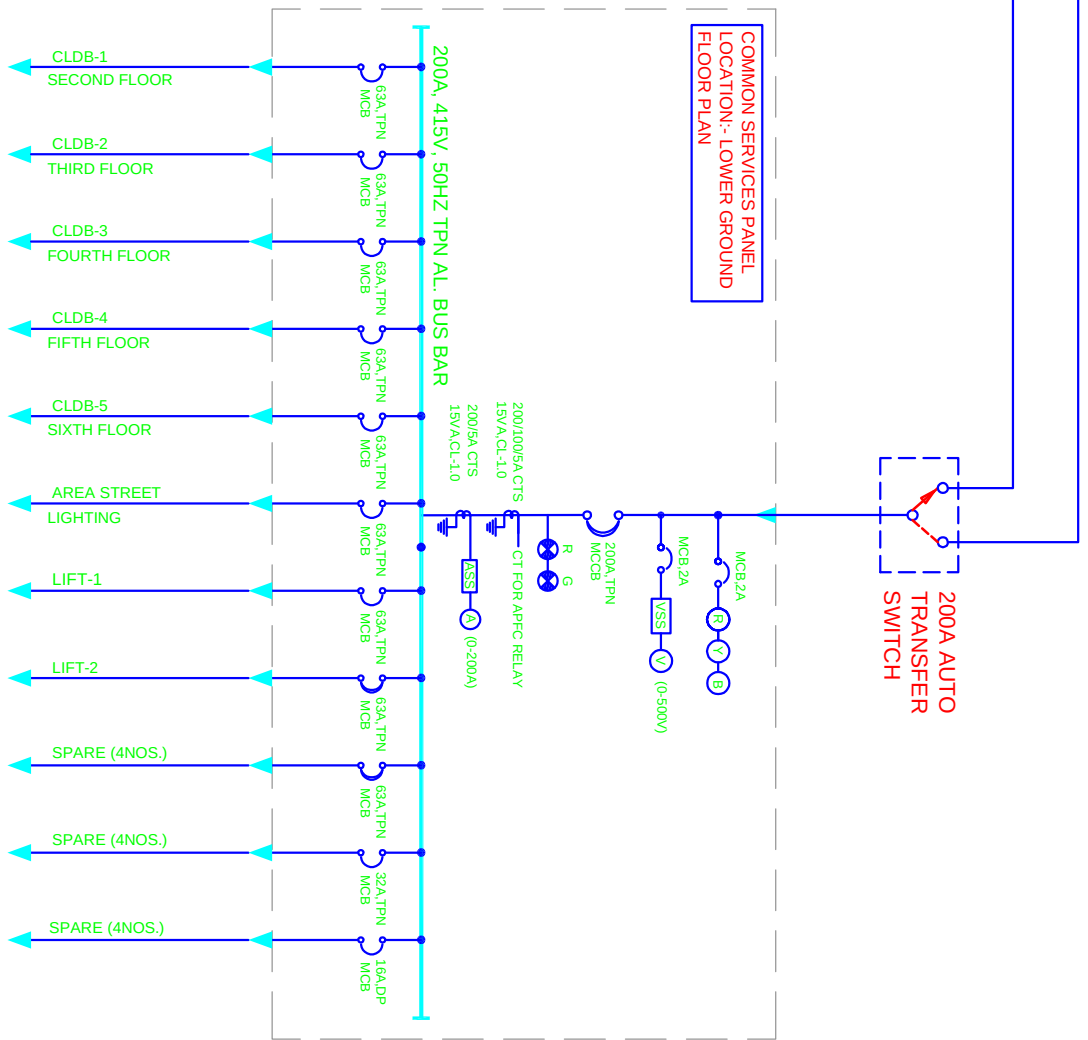