
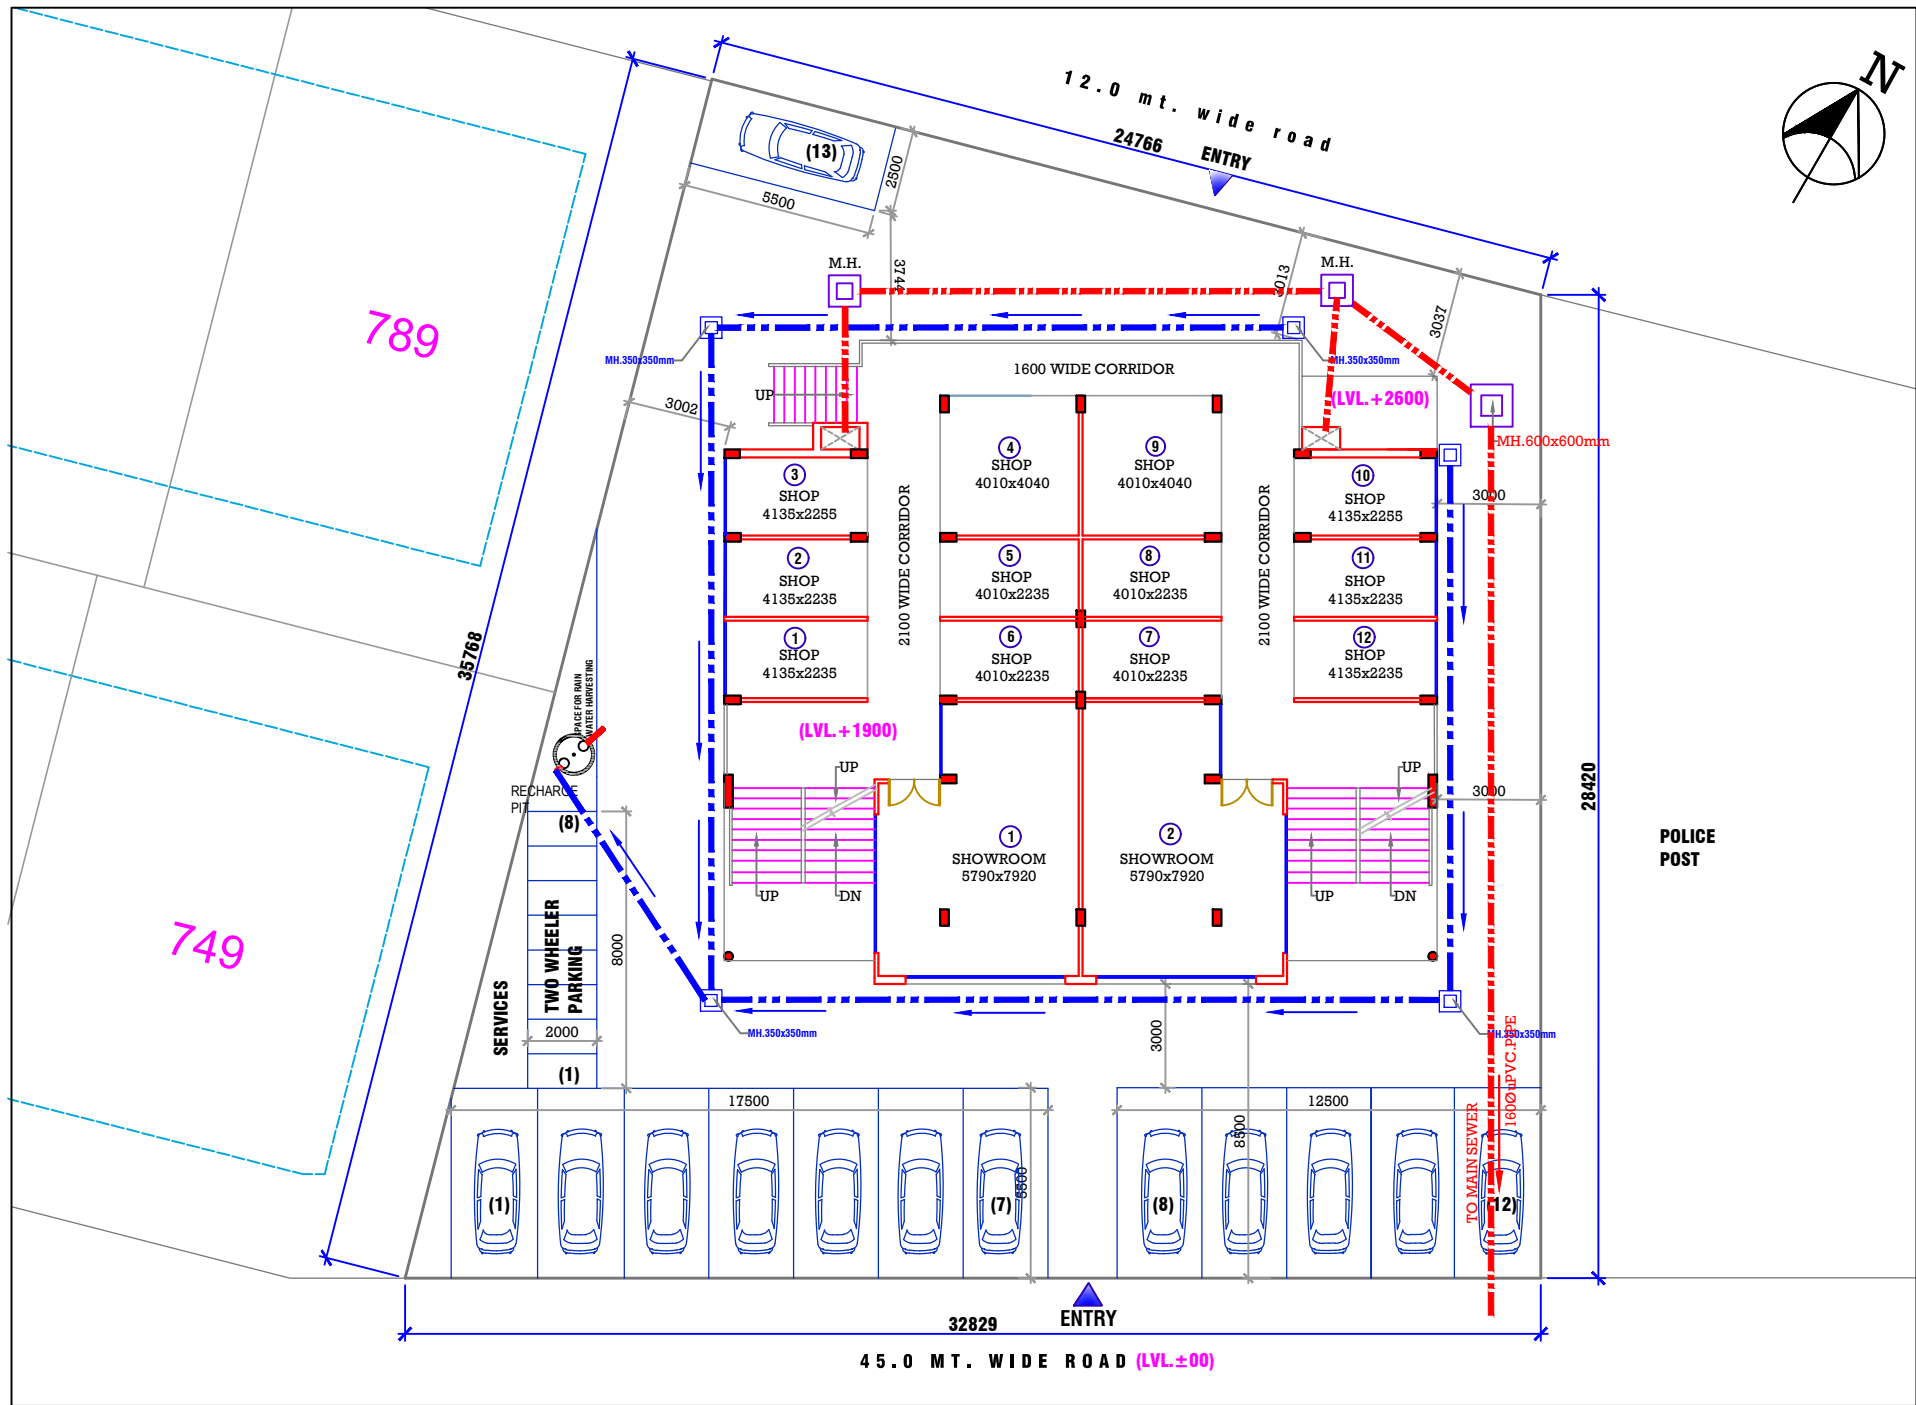


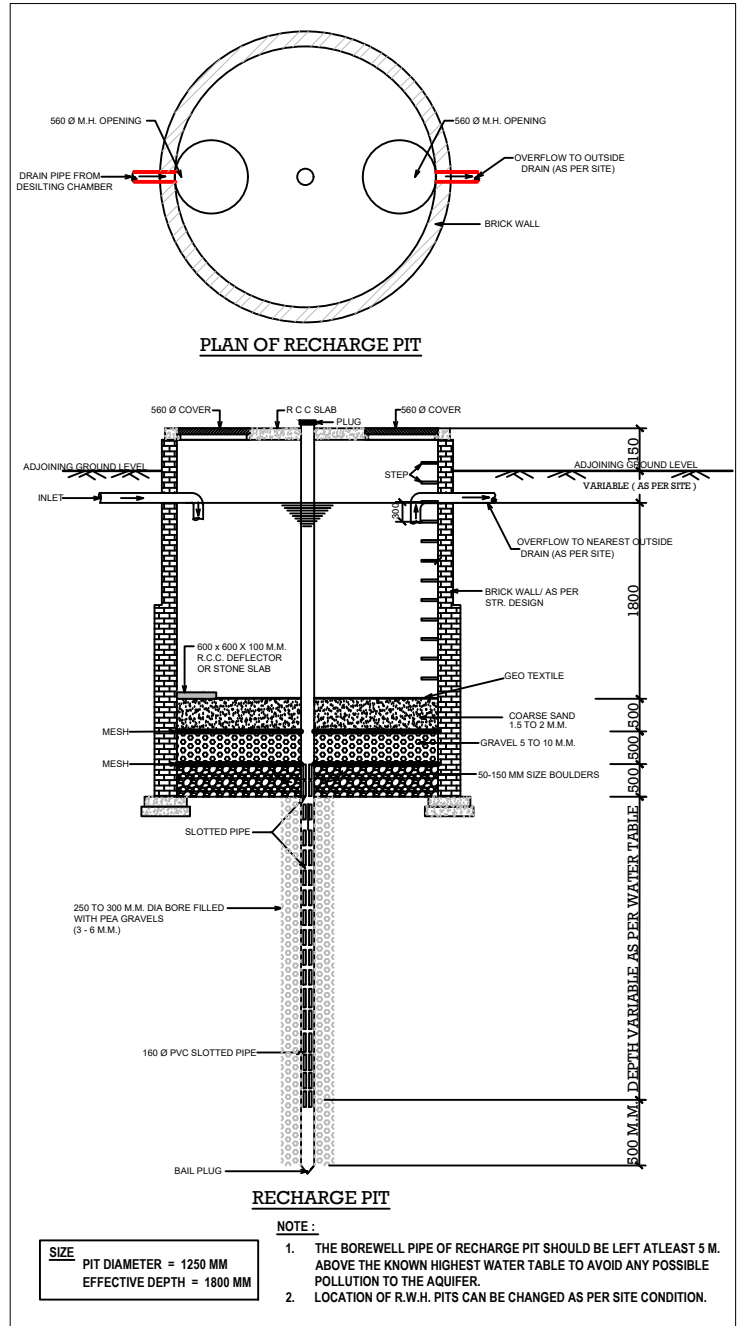

SEWER & DRAINAGE LAYOUT

SCALE=1:200

LEGEND :	
SYMBOL	DESCRIPTION
	SOIL PIPE
	WASTE PIPE
	MANHOLE(600x600)
	MANHOLE(350x350)
	RAIN WATER PIPE

<p>PROPOSED LOCAL SHOPPING, C-4 AT ELDECO CITY ,I.I.M. ROAD,LUCKNOW.</p>		DEVELOPER:	ARCHITECT
		<p> espaces</p> <p>Ar.Sanjay Kumar Gupta 108,F. Floor,Corporate Chamber-1, Vibhuti Khand,Gomti Nagar, Lucknow-226010 Ph.No.4065958,9415114589 email-espaces_arch@rediffmail.com</p>	
PROMOTER:	DRG. NO. :		
ELDECO CITY LTD.	Services/01		