


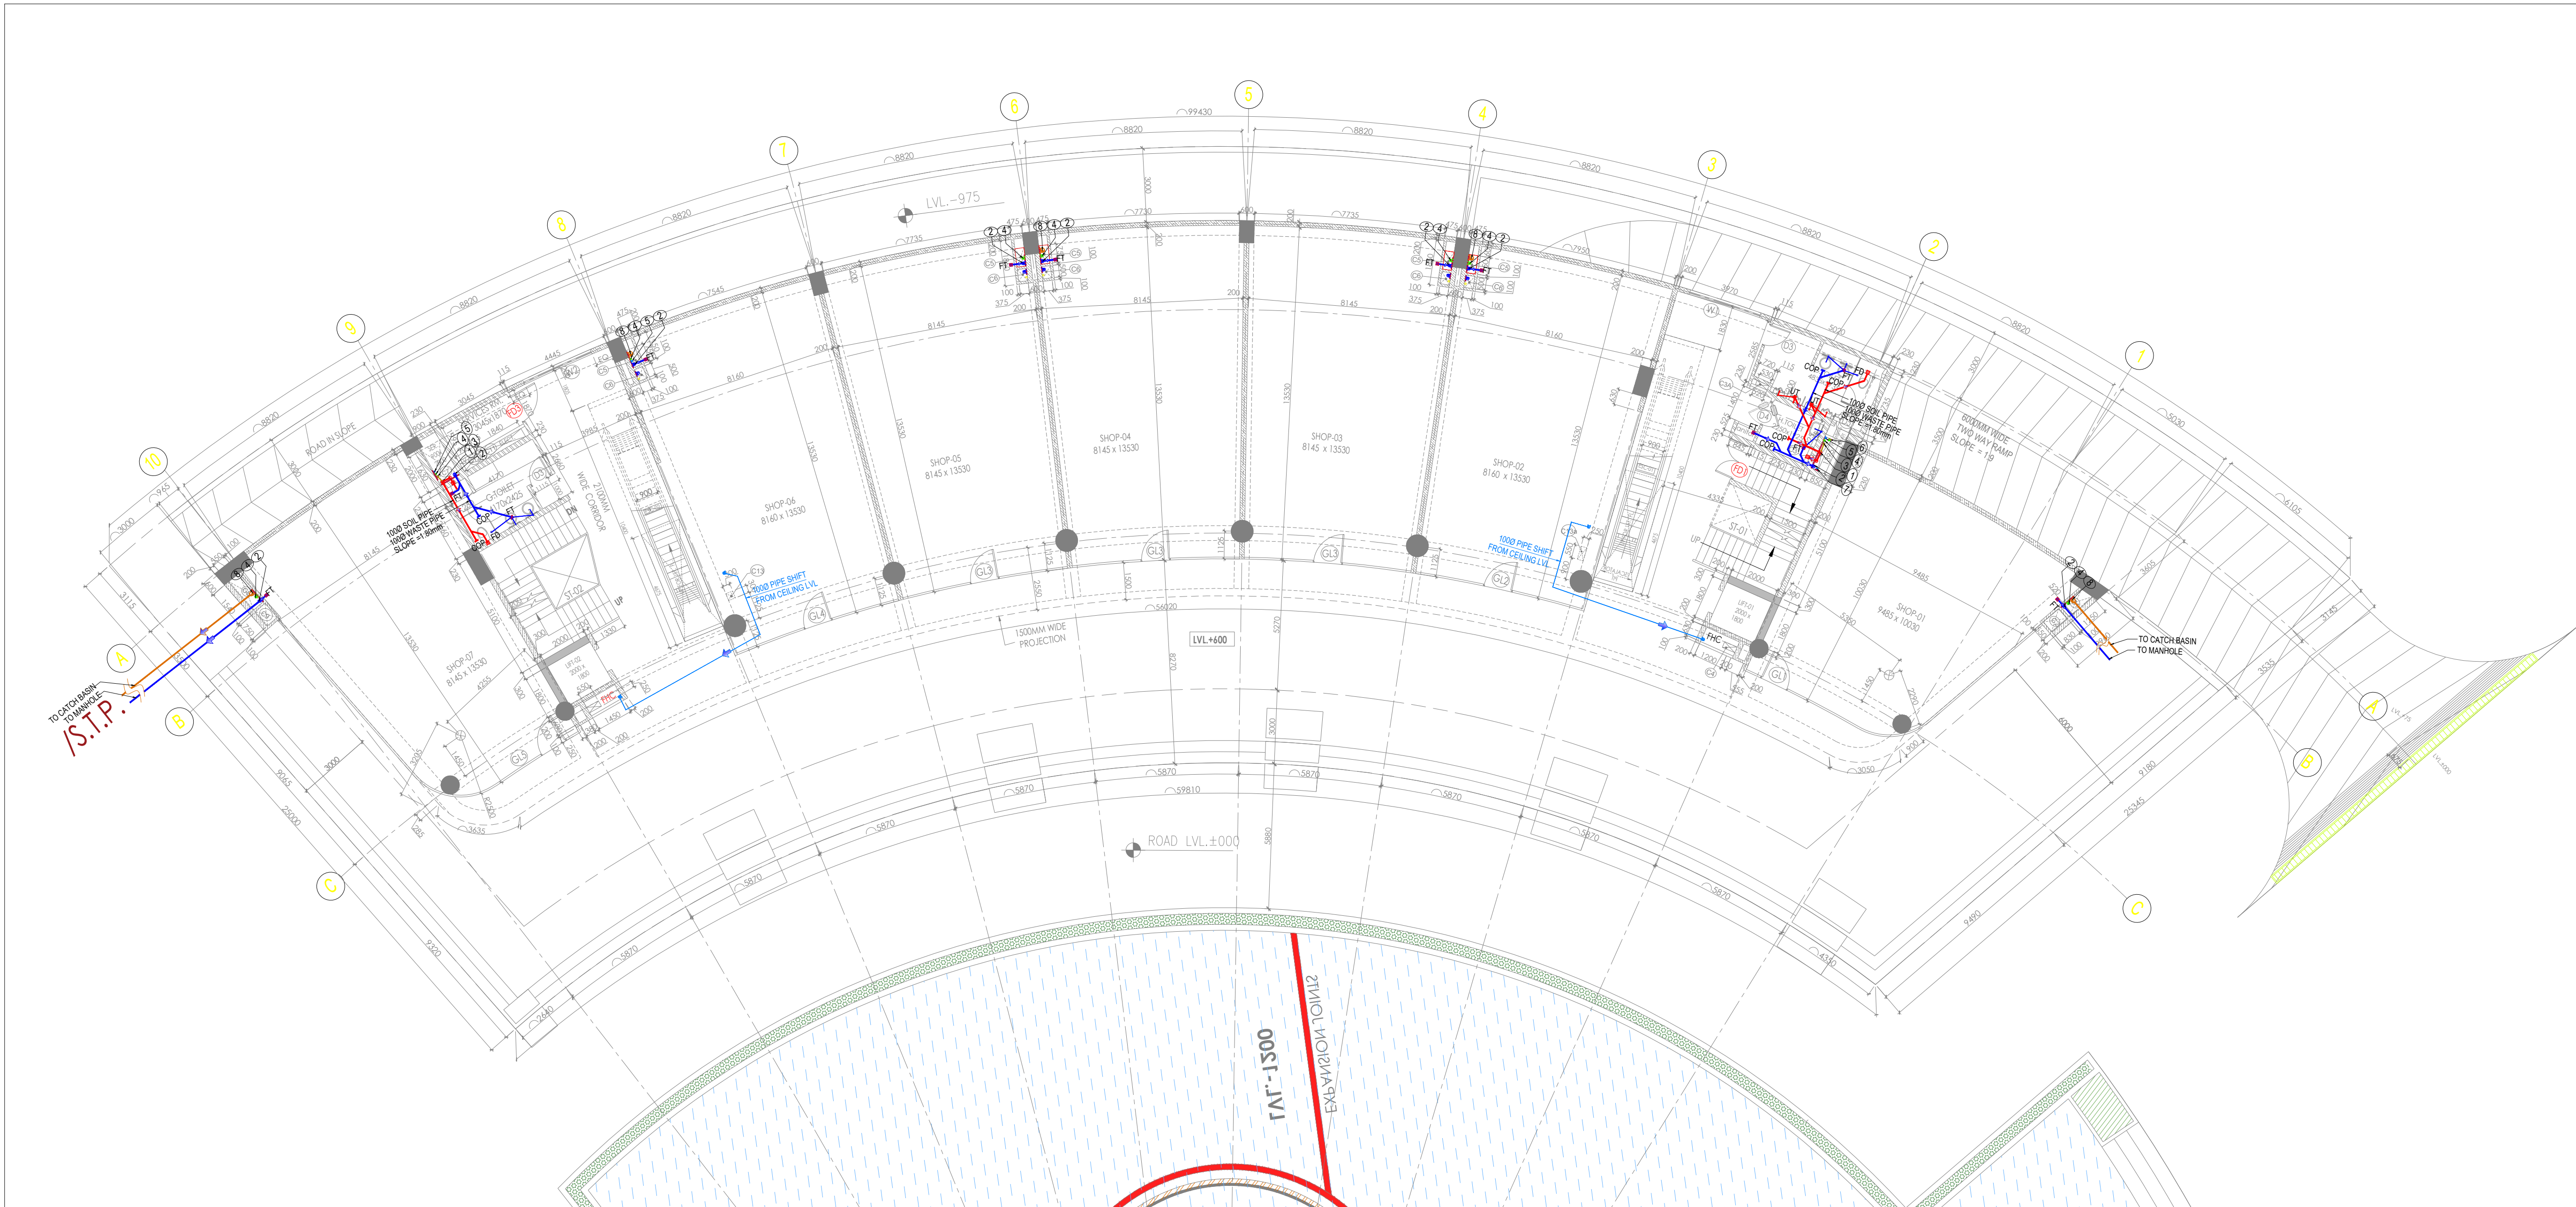

For Shalimar Lakecity Pvt. Ltd.
Authorised Signatory

SHIVAM SRIVASTAVA
ARCHITECT
CA20101050742

ARCHITECT SIGNATURE

LEGEND FOR PLUMBING		
1.		1000 SOIL PIPE
2.		1000 WASTE PIPE
3.		750 ANTISPONAGE PIPE
4.		DOMESTIC WATER SUPPLY PIPE
5.		FLUSHING WATER SUPPLY PIPE
6.		DOMESTIC WATER SUPPLY RISER PIPE
7.		FLUSHING WATER SUPPLY RISER PIPE
8.		1500 RAIN WATER PIPE
		VALVE
		FIRE HOSE CABINET

PIPE CONNECTION DIA :-	
WASH BASIN TO FT	320 WASTE PIPE
SINK TO FT	400 WASTE PIPE
FD TO FT WASTE PIPE	500 WASTE PIPE
FD TO VERTICAL PIPE	500 WASTE PIPE
FT TO VERTICAL WASTE PIPE	1000 WASTE PIPE
WC TO VERTICAL SOIL PIPE	1000 SOIL PIPE

COMMERCIAL-02 BUILDING
PLAN FOR M/S A.N.S DEVELOPER
(P). LTD.THROUGH ITS AUTHORIZED
SIGNATORY SHEO JANAM
CHOUDARI AT A.N.S INTEGRATED
TOWNSHIP, SHALIMAR ONE
WORLD, AT VILLAGE, BAGHAMAU,
LUCKNOW(KHASRA NUMBER PART
OF 360,361,362)
PROJECT NAME THE WALK-01

NOTES:-
1. ALL DIMENSIONS ARE IN MM.
2. DO NOT SCALE ANY DIMENSIONS.
3. THIS DRAWING SHALL BE READ IN
CONJUNCTION WITH RELEVANT
ARCHITECTURAL AND STRUCTURAL DRAWINGS.

KEY PLAN

CODE	DESCRIPTION

OWNER
SAS GROUP
SAS Home & Properties (P) Ltd.
Shalimar Square,
B N Road, Labagh, Lucknow

MASTER PLANNING
ATKINS
42mm ARCHITECTURE
D 102 Dr. Ambedkar Colony, Andheria Modh,
New Delhi

MEP CONSULTANT
PDA Consultants
MEP & Green Building Consultants
REGD OFFICE:
PLOT NO-103, SECOND FLOOR,
PATANGIRAU INDUSTRIAL AREA,
DELHI-110002, INDIA.
TEL:- +9111-4249301/4249302
E-MAIL: info@pdaconsultants.in

STRUCTURAL
MNC DESIGN INTERNATIONAL
CONSULTING STRUCTURAL ENGINEERS
PLOT NO-103, SECOND FLOOR,
PATANGIRAU INDUSTRIAL AREA,
DELHI-110002, INDIA.
TEL:- +9111-4249301/4249302
E-MAIL: info@mncdesign.in

LANDSCAPE

PROJECT
BAGHAMAU INTEGRATED TOWNSHIP
DEVELOPMENT, LUCKNOW
INDIA

ARCHITECT
SIKKA ASSOCIATES ARCHITECTS
A-321, VIKRUPA AVENUE, SARANSWARI ENCLAVE, NEW DELHI-110 029
T:- 011-26233551, F:- 011-26233552 | E: info@sikkaarch.com | W: www.sikkaarch.com

SEAL
ISSUED FOR
INFORMATION & REVIEW
TENDER
SUBMISSION
☒ GFC
AS BUILT

REVISIONS	DESCRIPTION
#	DATE

SCALE:- 1:100 (A1)
DATE:- 02.04.2023
DRAWN BY:- M.A
CHECKED BY:- P.J

DRAINAGE LAYOUT
COMMERCIAL-2 LAKESIDE
GROUND FLOOR PLAN
DRAWING NO. PDA-178/COMM-2/FF/PL/DR-02