

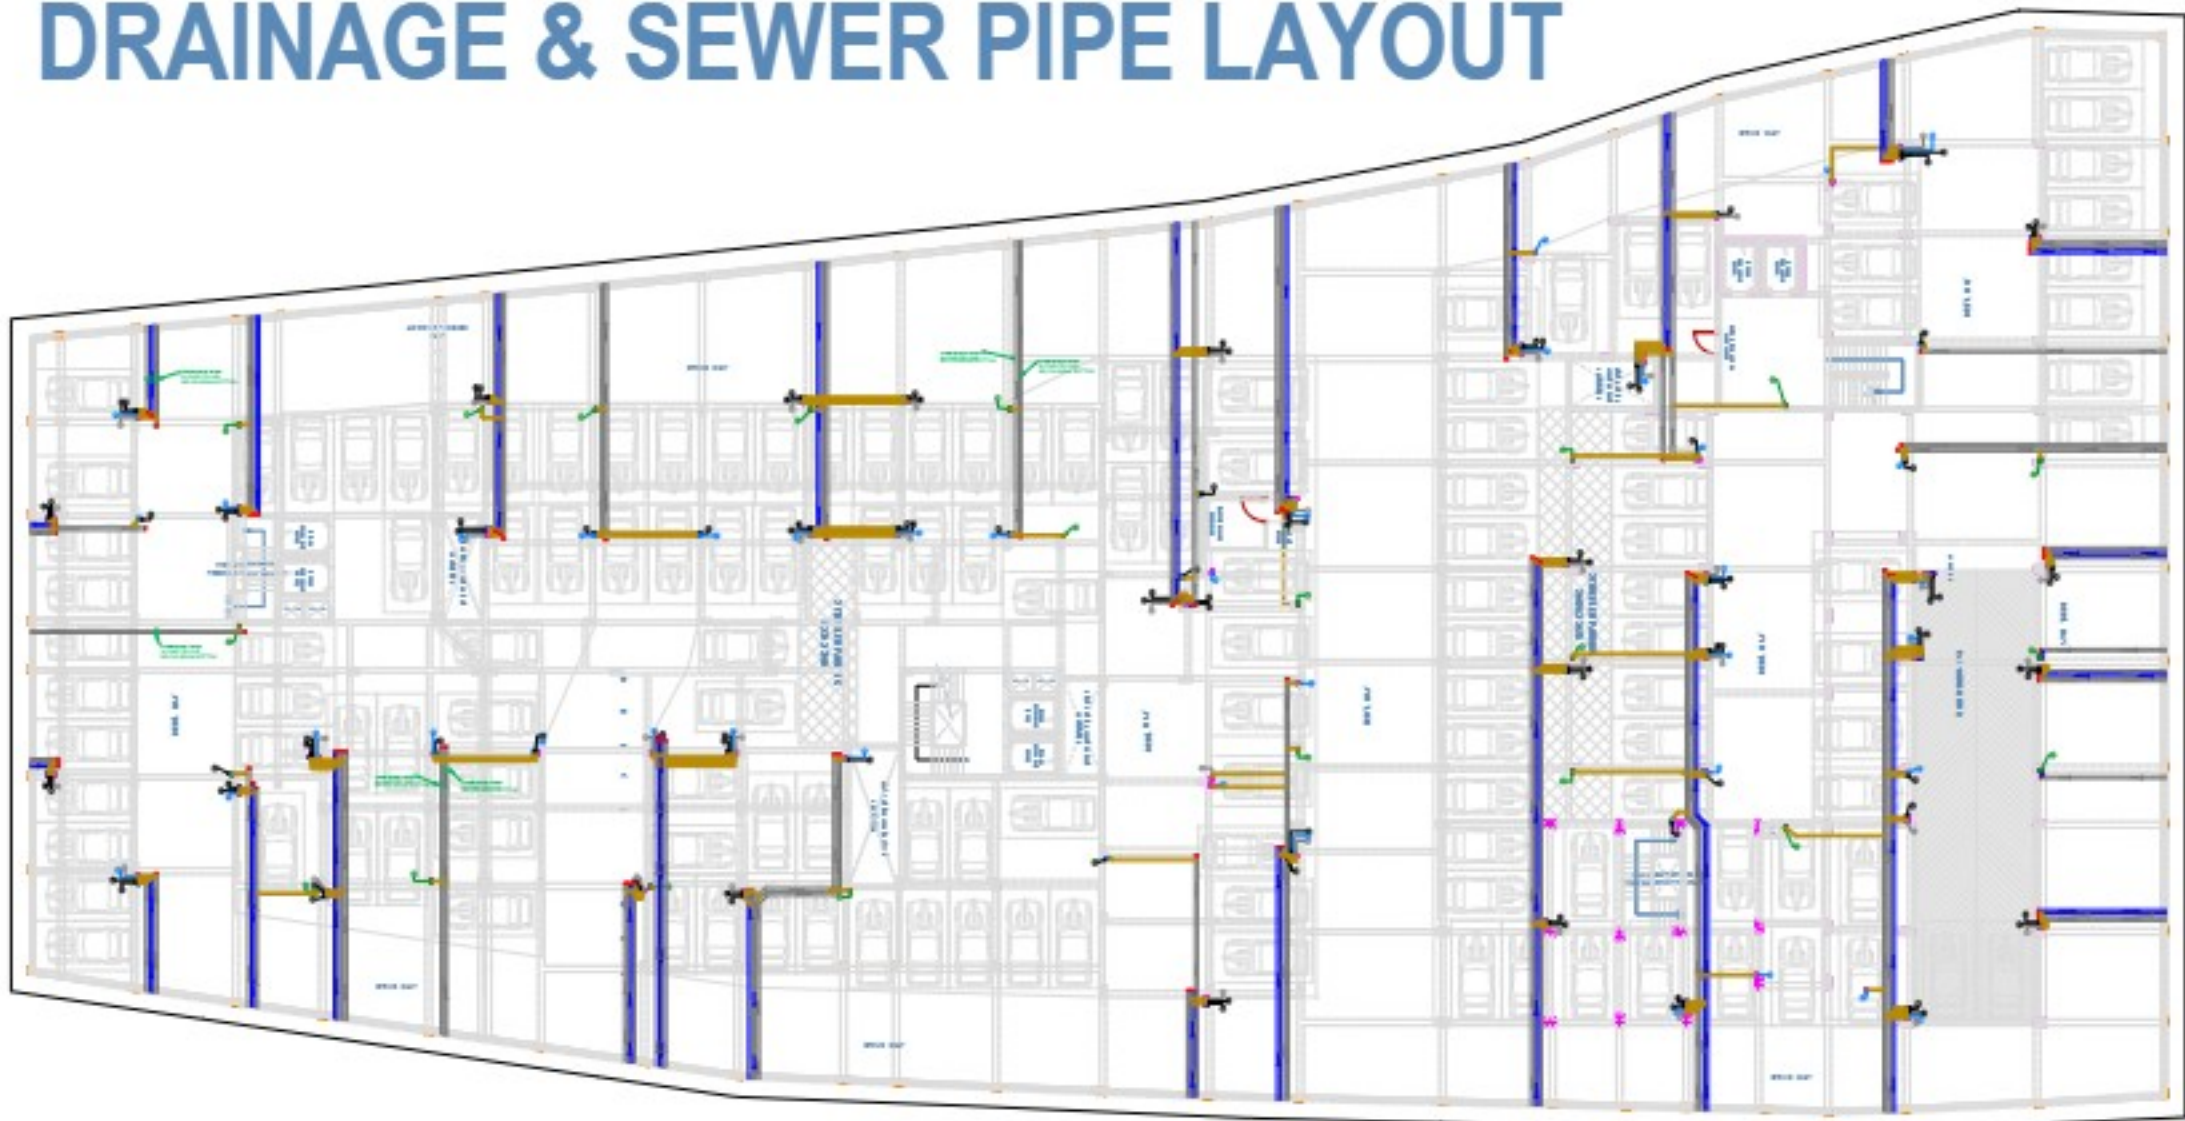



DRAINAGE & SEWER PIPE LAYOUT

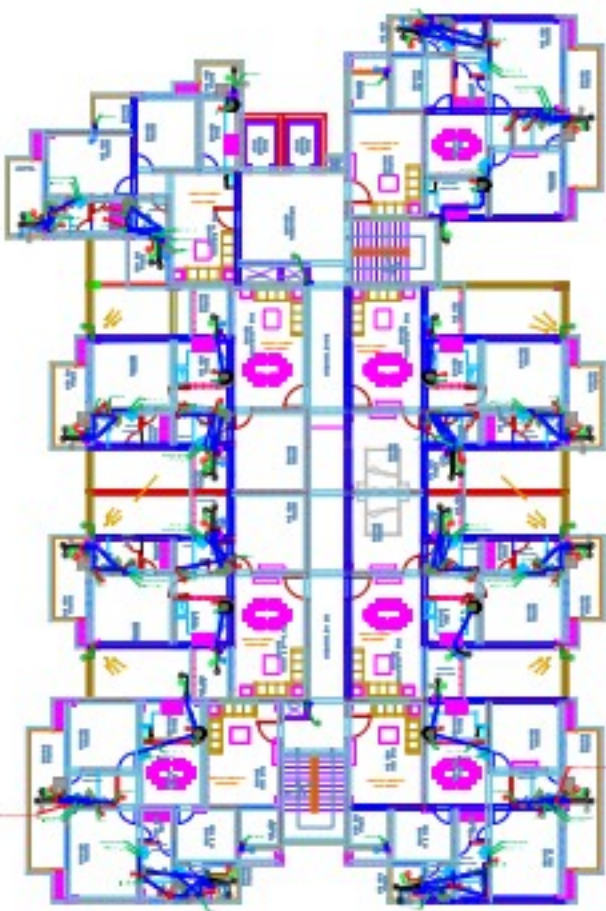


FIRST FLOOR PLAN (SANITARY)
TOWER-A

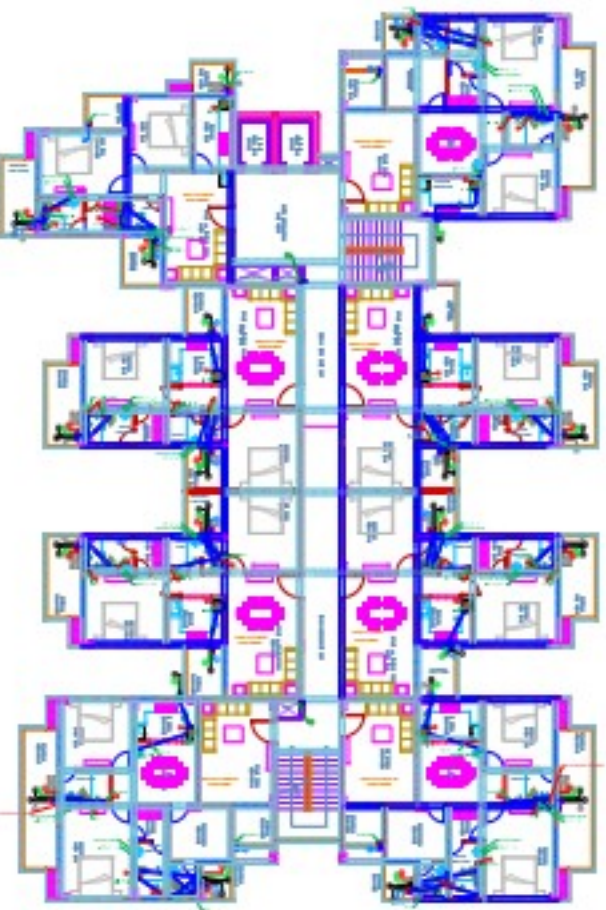

TYPICAL FLOOR PLAN (SANITARY)
TOWER-A

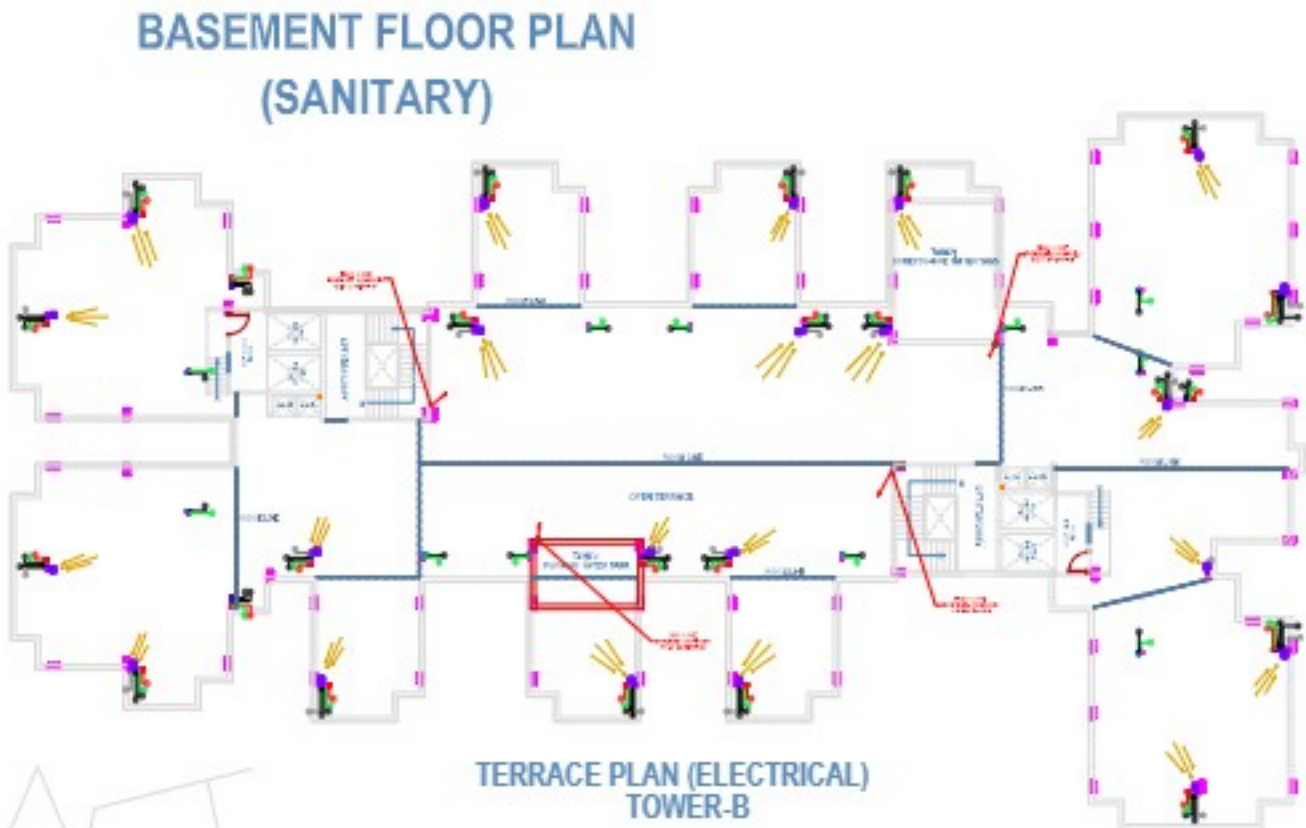

BASEMENT FLOOR PLAN
(SANITARY)

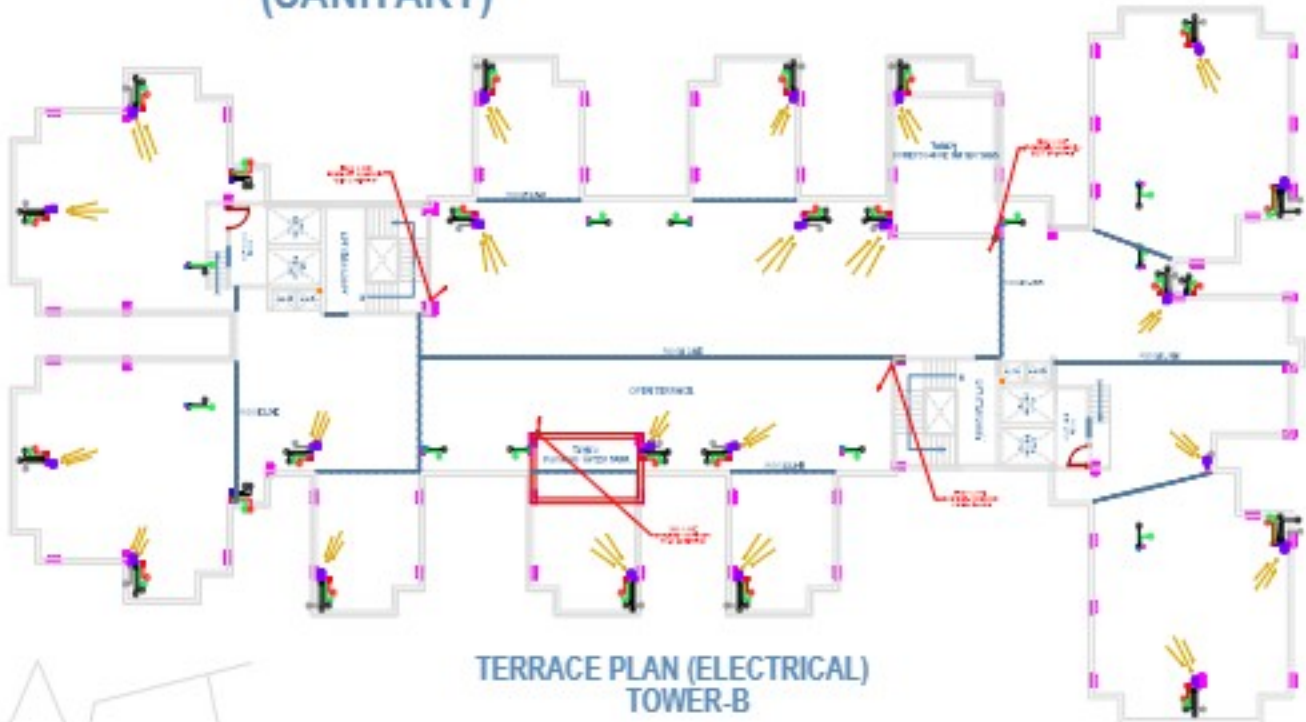


TERRACE PLAN (ELECTRICAL)
TOWER-B



FIRST FLOOR PLAN (SANITARY)
TOWER-B



TYPICAL FLOOR PLAN (SANITARY)
TOWER-B

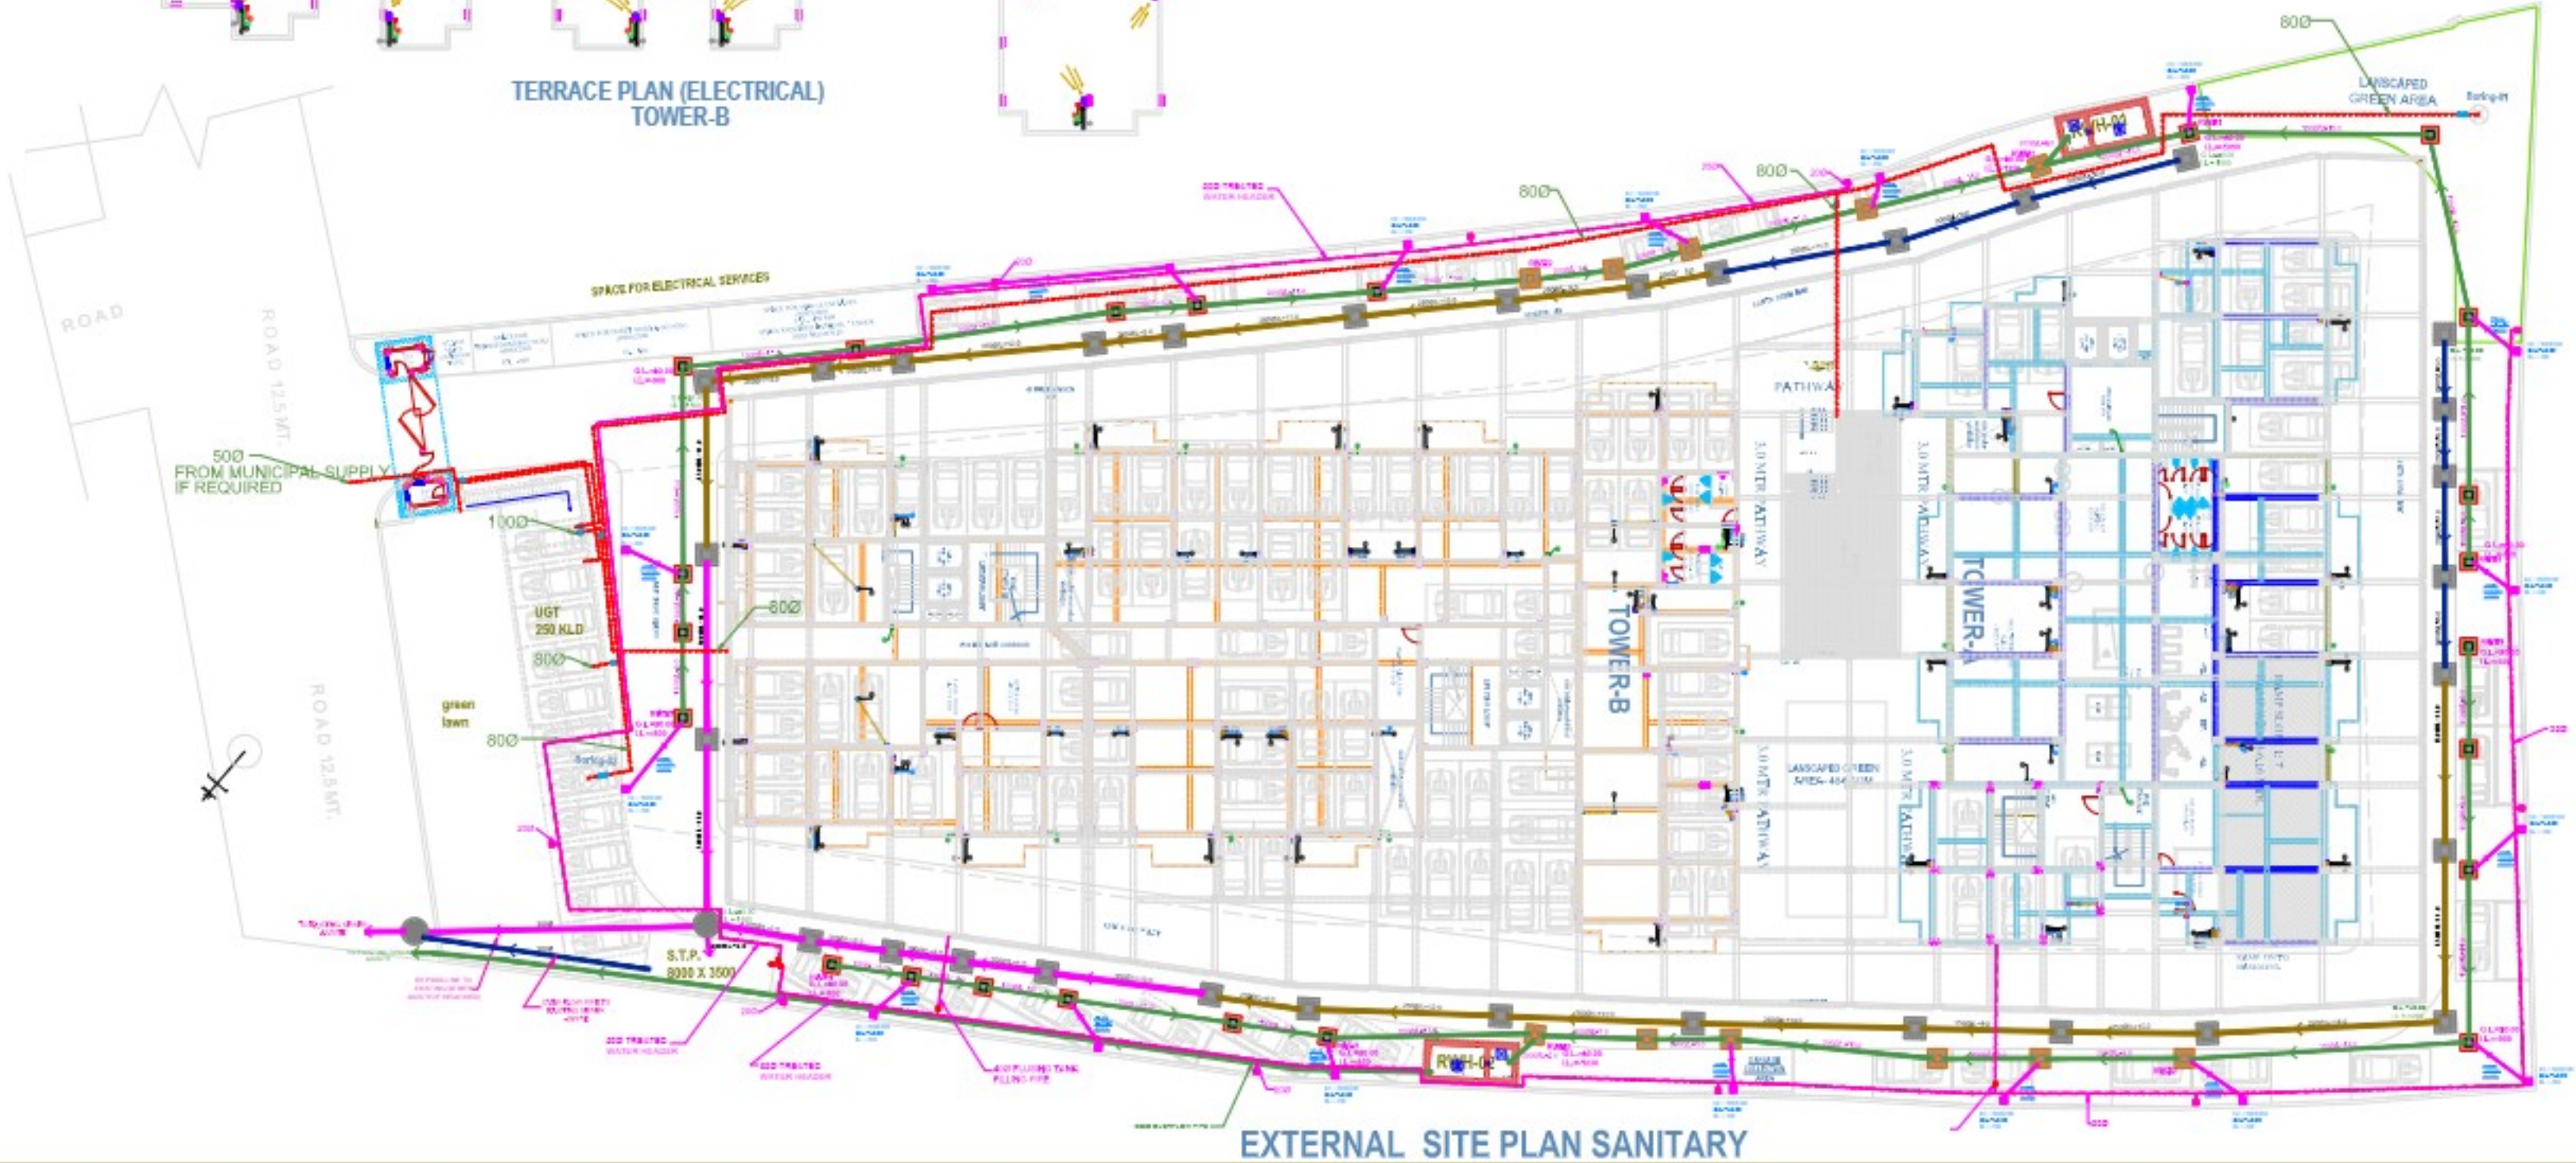

EXTERNAL SITE PLAN SANITARY

PROJECT TITLE:
PROPOSED APARTMENT (AMBA
HARMONY) FOR
AMBA HOUSING AT VILLAGE
AURANGABAD JAGEER WARD- RAJA
BIJALI PASI,
KANPUR ROAD LUCKNOW

JOB TITLE:
SERVICES

DRAWING TITLE:
SANITARY DRAWING (DRAINAGE & SEWER)

DATE:	REF.DWG.NO.:	NORTH
DRN:	SHEET NO.	
CHKD:		
TCD:		
SCALE:		

SERVICES (MEP) CONSULTANT:
SAHAYOG CONSULTANTS
Lucknow.
Ph. No.: +91-8840488408
email : sahayogconsultants@gmail.com

CONSULTING ARCHITECT:
ViViDA Architects & Associates
Architects: VIBHAV ANAND
MUKESH RAJ

LUCKNOW OFF. - B-310, VARDAN KHAND GOMTI NAGAR
EXT. SEC-01 LUCKNOW 226010

(MOB. - +91-9415363684)
(MOB. - +91-9919244223)
(MOB. - +91-9936944445)

E-mail: vividagroup2@gmail.com
website: www.vividagroup.co.in

FOR CONSTRUCTION AGENCY FOR VIVIDA ARCHITECTS

